

FINAL CONSTRUCTION PLANS

FOR

LEDER HILLSBORO

4191 W. HILLSBORO BOULEVARD
COCONUT CREEK, FL 33073



FEMA FLOOD ZONE:

THE PROPERTY IS LOCATED WITHIN FLOOD ZONES AE (16), X AND "0.2 PERCENT ANNUAL CHANCE FLOOD HAZARD" AS SHOWN ON F.I.R.M. No. 12011C0158H, BEARING A MAP EFFECTIVE DATE OF 08/18/2014.

RELATIONSHIP BETWEEN NGVD 1929 AND NAVD 1988		
ELEV.	DIFFERENCE	DATUM
1.55'	+1.55 FEET	NGVD 1929
0.00'		NAVD 1988

ALL ELEVATIONS SHOWN ON THESE PLANS
ARE BASED ON NAVD 1988 DATUM

LAND DESCRIPTION:

ALL OF PARCEL "A", "LEDER HILLSBORO COMPANY LIMITED - PART 2", ACCORDING TO THE PLAT THEREOF, AS RECORDED IN PLAT BOOK 166, PAGE 43, OF THE PUBLIC RECORDS OF BROWARD COUNTY, FLORIDA.

TOGETHER WITH:

ALL OF TRACT "A", "LEDER HILLSBORO COMPANY LIMITED - PART 1", ACCORDING TO THE PLAT THEREOF, AS RECORDED IN PLAT BOOK 125, PAGE 31, OF THE PUBLIC RECORDS OF BROWARD COUNTY, FLORIDA

SAID LANDS LYING IN THE CITY OF COCONUT CREEK, BROWARD COUNTY, FLORIDA.



LOCATION MAP

SECTION 05, TOWNSHIP 48 S, RANGE 42 E
FOLIO NUMBER 4842 05 24 0010

INDEX OF SHEETS		
Sheet Sequence No.	Sheet Identification	Sheet Title
-	GI-000	COVER
1	GI-001	LEGEND
2	GI-002	CONSTRUCTION SPECIFICATIONS
3	GI-003	GENERAL NOTES
4 - 5	CG-101 - CG-102	STORM WATER POLLUTION PREVENTION PLANS
6 - 7	CG-501 - CG-502	STORM WATER POLLUTION PREVENTION DETAILS
8 - 9	CD-101 - CD-102	DEMOLITION PLANS
10 - 11	CP-101 - CP-102	PAVING, GRADING AND DRAINAGE PLANS
12 - 15	CP-501 - CP-504	PAVING, GRADING AND DRAINAGE DETAILS
16 - 17	CU-101 - CU-102	WATER AND SEWER PLANS
18 - 21	CU-501 - CU-504	WATER AND SEWER DETAILS
22 - 23	CM-101 - CM-102	PAVEMENT MARKING AND SIGNAGE PLANS
24	CM-501	CITY PAVEMENT MARKING AND SIGNAGE DETAILS
25 - 26	CM-502 - CM-503	PAVEMENT MARKING AND SIGNAGE DETAILS
27	CT-501	MAINTENANCE OF TRAFFIC

THE PUBLIC ROADWAY(S) INDICATED IN THESE PLANS HAVE BEEN DESIGNED IN ACCORDANCE WITH THE "MANUAL OF UNIFORM MINIMUM STANDARDS FOR DESIGN, CONSTRUCTION AND MAINTENANCE FOR STREETS & HIGHWAYS - STATE OF FLORIDA.

THESE PLANS MAY HAVE BEEN
REDUCED IN SIZE BY REPRODUCTION.
THIS MUST BE CONSIDERED WHEN
OBTAINING SCALED DATA.



PREPARED FOR:
THE LEDER GROUP
4755 TECHNOLOGY WAY, SUITE 203
BOCA RATON, FL 33431

BROWARD COUNTY HIGHWAY CONSTRUCTION
AND ENGINEERING DIVISION

☐ PLAT CONSISTENT WITH PLAT REQUIREMENTS
PUBLIC R/W

☐ PUBLIC RIGHT OF WAY APPROVAL FOR
PAVING, GRADING AND DRAINAGE

BY: _____ DATE: _____

DOES NOT INCLUDE APPROVAL OF PAVEMENT MARKINGS & SIGNS



301 East Atlantic Boulevard
Pompano Beach, Florida 33060-6643
(954) 788-3400

State of Florida Certificate of
Authorization Number - 7928

PROJECT No. 09675.00 DATE: 03/28/2017

STEPHEN D. WILLIAMS, P.E.
FLORIDA REG. NO. 32090
(FOR THE FIRM)

REVISIONS

[illegible]

SCALE:	AS NOTED
DATE ISSUED:	JANUARY 31, 2018
DRAWN BY:	MG
DESIGNED BY:	MG
CHECKED BY:	SW

 
STEPHEN D. WILLIAMS, P.E.
FLORIDA REG. NO. 32090
(FOR THE FIRM)

LEGEND

GI-001

PROJECT NO. 09675.00

Existing	Proposed	Description
		Bush
		Tree
		Palm Tree

Drainage / Utilities		
Existing	Proposed	Description
		Catch Basin
		Yard Drain
		Exfiltration Trench
		Catch Basin With Filter Fabric Insert
		Curb Type 5
		Curb Type 6
		Pipe Culvert - Mitered End Section
		Pipe Culvert - Straight Endwall
		Pipe Culvert - U - Type Endwall

	Abbreviations
General	
AADT	Annual Average Daily Traffic
ABAN	Abandon
ADJ	Adjust
APPROX.	Approximate
A.C.	Asphalt Concrete
ACCM PIPE	Asphalt Coated Corrugated Metal Pipe
BIT.	Bituminous
BC	Back Of Curb
BD.	Bound
BL	Baseline
BLDG	Building
BM	Benchmark
BO	By Others
BOS	Bottom Of Slope
BR.	Bridge
CAP	Corrugated Aluminum Pipe
CB	Catch Basin
CBCI	Catch Basin With Curb Inlet
CC	Cement Concrete
CCM	Cement Concrete Masonry
CEM	Cement
CI	Curb Inlet
CIP	Cast Iron Pipe
CLF	Chain Link Fence
CL	Centerline
CMP	Corrugated Metal Pipe
CO.	County
CONC	Concrete
CONT	Continuous
CONST	Construction
CR GR	Crown Grade
DHV	Design Hourly Volume
DI	Drop Inlet
DIA	Diameter
DIP	Ductile Iron Pipe
DWY	Driveway
ELEV (OR EL.)	Elevation
EMB	Embankment
EOP	Edge Of Pavement
EXIST (OR EX)	Existing
EXC	Excavation
F&C	Frame And Cover
F&G	Frame And Grate
FDN.	Foundation
FLDSTN	Fieldstone
GAR	Garage
GD	Ground
GI	Gutter Inlet
GIP	Galvanized Iron Pipe
GRAN	Granite
GRAV	Gravel
GRD	Guard
GV	Gate Valve
HDW	Headwall
HMA	Hot Mix Asphalt
HOR	Horizontal
HYD	Hydrant
INV	Invert
JCT	Junction
L	Length Of Curve
LB	Leach Basin
LP	Light Pole
LT	Left
MAX	Maximum
MB	Mailbox
MH	Manhole
MIN	Minimum
NIC	Not In Contract
NO.	Number
PC	Point Of Curvature
PCC	Point Of Compound Curvature
P.G.L.	Profile Grade Line

CONSTRUCTION SPECIFICATIONS

Section 20 - General Specifications Paving Grading Drainage and Earthwork

20.General

20.1. It is the intent of these specifications to describe the minimum acceptable technical requirements for the materials and workmanship for construction of site improvements for this project. Such improvements may generally include, but not to be limited to, clearing, grading, paving, removal of existing pavement storm drainage, water lines and sanitary sewers.

20.2. It is the intent that the Florida Department of Transportation (FDOT) "Standard Specifications for Road and Bridge Construction: (current edition) together with "Supplemental Specifications to the Standard Specifications for Road and Bridge Construction" (current edition), and the FDOT Roadway and Traffic Design Standards (current edition) be used where applicable for the various work, and that where such wording therein refers to the State of Florida and its Department of Transportation and personnel, such wording is intended to be replaced with the wording which would provide proper terminology; thereby making such "Standard Specifications for Road and Bridge Construction" together with the "FDOT Roadway and Traffic Design Standards" as the "Standard Specifications" for this project. If within a particular section, another section, article or paragraph is referred to, it shall be part of the Standard Specifications also. The Contractor shall abide by all local and State laws, regulations and building codes which have jurisdiction in the area.

20.3. The Contractor shall furnish all labor, materials and equipment and perform all operations required to complete the construction of a paving and drainage system as shown on the plans, specified herein, or both. It is the intent to provide a complete and operating facility in accordance with these specifications and the construction drawings. The material and equipment shown or specified shall not be taken to exclude any other incidentals necessary to complete the work.

20.4. All labor, materials, and methods of construction shall be in strict accordance with the plans and construction specifications and the minimum engineering and construction standards adopted by the unit of government which has jurisdiction and responsibility for the construction. Where conflicts or omissions exist, the jurisdictional government Engineering Department's standards shall govern. Substitutions and deviations from plans and specifications shall be permitted only when written approval has been issued by the Engineer.

20.5. Guarantee - all materials and equipment to be furnished and/or installed by the Contractor under this contract, shall be guaranteed for a period of (l) one year from the date of final acceptance thereof, against defective materials, design and workmanship. Upon receipt of notice from the owner of failure of any part of the guaranteed equipment or materials, during the guarantee period, the affected part or materials shall be replaced promptly with new parts or materials by the contractor, at no expense to the owner. In the event the Contractor fails to make necessary replacement or repairs within (7) seven days after notification by the owner, the owner may accomplish the work at the expense of the contractor.

21.Earthwork

21.1. All areas within the project limits shall be cleared and grubbed prior to construction. This shall consist of the complete removal and disposal of all trees, brush, stumps, roots, grass, weeds, rubbish and all other obstructions resting on or protruding through the surface of the existing ground to a depth of 1'. All work shall be in accordance with section 110 of the Standard Specifications.

21.2. None of the existing limerock material from demolished pavement is to be incorporated in the new limerock base, unless noted in plans. The existing limerock material from demolished pavement may be incorporated into the stabilized subgrade / subbase, or stabilized shoulder.

21.3. Fill material shall be classified as A-I, A-3, or A-2-4 in accordance with AASHTO N-145 and shall be free from vegetation and organic material. Not more than 12% by weight of fill material shall pass the no. 200 sieve.

21.4. All fill material in areas not to be paved shall be compacted to 95% of the maximum density as determined by AASHTO T-99.

21.5. All material of construction shall be subject to inspection and testing to establish conformance with the specifications and suitably for the uses intended. The Contractor shall notify the Engineer at least 24 hours prior to the time he will be ready for an inspection or test. The Contractor shall follow City and County inspection procedures. The Contractor shall not proceed with any phase of work dependent on an inspection or test of an earlier phase of work, prior to that test or inspection passing. The Contractor shall be responsible for providing certified material test results to the Engineer of record prior to the release of final certification by the Engineer. Test results must include, but may not be limited to, densities for subgrade and limerock, utilities, excavation, asphalt gradation reports, concrete cylinders, etc.

21.6. When encountered, muck shall be completely removed from the center line (10) ten feet beyond the edge of pavement each side. All such material shall be replaced by approved granular fill.

21.7. When encountered within drainage swales, hardpan shall be removed to full depth for a width of (5) five feet at the invert and replaced with granular materials.

21.8. All underground utilities and drainage installations shall be in place prior to subgrade compaction and pavement construction.

21.9. Ground adjacent to roadway/pavement having runoff shall be graded (2) two inches lower than the edge of pavement to allow for the placement of sod.

21.10.Site grading elevations shall be within 0.1' of the required elevation for non paved areas and all areas shall be graded to drain without ponding.

21.11.The Contractor shall perform all excavation, fill, embankment and grading to achieve the proposed plan grades including typical road sections, side slopes and canal sections. All work shall be in accordance with section 120 of the Standard Specifications. If fill material is required in excess of that generated by the excavation, the Contractor shall supply this material as required from off-site.

21.12.A 2" blanket of top soil shall be placed over all areas to be sodded or seeded and mulched within the project limits unless otherwise indicated

on the plans.

21.13.Sod shall be St. Augustine unless otherwise indicated on the plans, and shall be placed on the graded top soil and watered to insure satisfactory condition upon final acceptance of the project.

22.Drainage

22.1. Inlets - all inlets shall be the type designated on the plans, and shall be constructed in accordance with section 425 of the Standard Specifications. All inlets and pipe shall be protected during construction to prevent siltation in the drainage systems by way of temporary plugs and plywood or plastic covers over the inlets. The entire drainage system shall be cleaned of all debris prior to final acceptance.

22.2. Pipe specifications: the material type is shown on the drawings by one of the following designations:

- RCP = reinforced concrete pipe, ASTM designation C--76, section 941 of the Standard Specifications.
- CMP = corrugated metal (aluminum) pipe, ASTM designation M-196.
- CMP (smooth lined) = corrugated metal aluminum pipe, (smooth lined) ASTM designation M-196.
- SCP = slotted concrete pipe, sections 941 and 942, of the Standard Specifications.
- PVC = polyvinyl chloride pipe.
- PCMP = perforated cmp, section 945, of the Standard Specifications
- Corrugated High Density Polyethylene Pipe (HDPE) (12 Inches to 60 Inches), shall meet the requirements of FDOT Specification section 948-2.3.

22.3. Pipe backfill - requirements for pipe backfill crossing roads or parking areas shall be as defined in the section 125-8, of the Standard Specifications. Pipeline backfill shall be placed in 6 inch lifts and compacted to 100% of the standard proctor (AASHTO T--99 specifications)

22.4. Location of drainage structures shall govern, and pipe length may have to be adjusted to accomplish construction as shown on these plans.

22.5. Distance and lengths shown on plans and profile drawings are referenced to the inner walls of structures.

22.6. Filter fabric shall be Mirafi, Typar or equal conforming to section 985 of the Standard Specifications.

23.Asphalt Paving

23.1. Where new asphalt meets existing asphalt, the existing asphalt shall be saw cut to provide a straight even line. Prior to removing curb or gutter, the adjacent asphalt shall be saw cut to provide a straight even line.

23.2. Internal asphalt paving constructed on existing sandy soils shall be constructed with a 12" subgrade, compacted to a minimum density of 98% maximum density as determined by AASHTO T-180. The compacted subgrade shall be constructed in the limits shown on the plans. All subgrade shall have an LBR of 40 unless otherwise noted.

23.3. Asphaltic concrete surface course shall be constructed to the limits shown on the plans. The surface course shall consist of the thickness and type asphaltic concrete as specified in the plans. All asphaltic concrete shall be in accordance with sections 320, 327, 330, 334, 336, 337, 337, 338, 339 and 341 of the Standard Specifications.

23.4. Limerock base shall be prepared, compacted and graded and shall be in accordance with section 200 of the Standard Specifications. All limerock shall be compacted to 98% per AASHTO T-180 and have not less than 70% of carbonates of calcium and magnesium unless otherwise designated. The Engineer shall inspect the completed base course and the Contractor shall correct any deficiencies and clean the base course prior to the placement of the prime coat. A tack coat will also be required if the Engineer finds that the primed base has become excessively dirty or the prime coat has cured to the extent of losing bounding effect prior to placement of the asphaltic concrete surface course. The prime and tack coats shall be in accordance with section 300 of the Standard Specifications.

23.5. Limerock base material shall be placed in maximum 6" lifts. Bases greater than 6" shall be placed in two equal lifts. If, through field tests, the Contractor can demonstrate that the compaction equipment can achieve density for the full depth of a thicker lift, and if approved by the engineer, the base may be constructed in successive courses of not more than 8 inches (200 mm) compacted thickness.

23.6. Asphalt edges that are not curbed shall be saw cut to provide a straight even line to the dimensions shown on plans.

24.Concrete Construction

24.1. Concrete sidewalk shall be in accordance with section 522 of the Standard Specifications and in accordance with F.D.O.T. Roadway and Traffic Design Standards, index no. 310. Concrete sidewalk shall be 4" thick, unless otherwise not and constructed on compacted subgrade, with 1/2" expansion joints placed at a maximum of 75', unless otherwise noted on plans. Crack control joints shall be 5' on center. All concrete sidewalks that cross driveways shall be 6" thick, unless otherwise noted on plans.

24.2. Sidewalk Curb ramps hall be in accordance with F.D.O.T. Roadway and Traffic Design Standards, index no. 304.

24.3. Concrete curb shall be constructed to the limits shown on the plans. The concrete shall have a minimum compressive strength of 2500 PSI at 28 days and shall be in accordance with section 520 of the Standard Specifications. Concrete curbing shall be in accordance with F.D.O.T. Roadway and Traffic Design Standards, index no. 300.

24.4.

Section 30 - Water distribution and sanitary sewer force mains.

30. Materials:

Note: If materials list here on are in conflict with utility owner, material owner requirements shall govern.

30.1. All water main pipe, including fittings, shall be color coded or marked using blue as a predominant color to differentiate drinking water from reclaimed or other water. Underground plastic pipe shall be solid-wall blue pipe, shall have a co-extruded blue external skin, or shall be white or black pipe with blue stripes incorporated into, or applied to, the pipe wall; and underground metal or concrete pipe shall have blue stripes applied to the pipe wall. Pipe striped during manufacturing of the pipe shall have continuous stripes that run parallel to the axis of the pipe, that are located at no greater than 90-degree intervals around the pipe,

and that will remain intact during and after installation of the pipe. If tape or paint is used to stripe pipe during installation of the pipe, the tape or paint shall be applied in a continuous line that runs parallel to the axis of the pipe and that is located along the top of the pipe; for pipes with an internal diameter of 24 inches or greater, tape or paint shall be applied in continuous lines along each side of the pipe as well as along the top of the pipe.

30.2. Ductile iron pipe for water distribution mains shall conform to ANSI/AWWA standard C151/A21.51 latest revision, "ductile iron pipe centrifugally cast in metal molds or sand-lined molds" with a minimum wall thickness of class 51 (pressure class 350) unless otherwise noted in the plans. Ductile iron pipe shall be cement lined and seal coated in accordance with ANSI/AWWA standard C104/A21.4 latest revision. The pipe shall be adapted for use with class 250 fittings for all sizes. Water main shall be colored blue in accordance with Florida State Statutes.

30.3. Ductile iron pipe for sewage force mains shall conform to ANSI/AWWA standard C151/A21.51 latest revision, "ductile iron pipe centrifugally cast in metal molds or sand- lined molds" with a minimum wall thickness of class 51 (pressure class 350) unless otherwise noted in the plans. Ductile iron pipe shall be interior ceramic epoxy lined and exterior coated with the manufacturer's coating system (Protecto 401 ceramic epoxy with a minimum dry film thickness of 40 mils and an outside coating of either coal tar epoxy or asphalt). Cement mortared linings are not appropriate for this application.

30.4. All pipe & fittings on the lift station sites shall be ductile iron conforming to the same specifications as above for sewage force mains except that flanged ductile iron pipe & fittings shall be used inside valve pits and wet wells. Flanged pipe and fittings shall conform to ANSI/AWWA C115/a21.15 latest revision and ANSI/AWWA C110/A21.10 latest revision. The following thickness classes shall be adhered to: 4" - 12" - class 52, 14" & larger - class 51.

30.5. PVC pressure pipe for sizes 4" through 12" and shall conform to ANSI/AWWA standard C900 latest revision. PVC pressure pipe shall be made from class 12454-a or class 12454-b virgin material and conform with the outside diameter of cast iron pipe with a minimum wall thickness of dr series 18. Ultra violet degradation or sun bleached pipe will be cause for rejection. Water main shall be colored blue in accordance with Florida State Statutes. Force main shall be impregnated with green pigment. Reuse main shall be impregnated with purple pigment.

30.6. Ductile iron fittings for water distribution mains shall conform to ANSI/AWWA standard C110/A21.10 latest revision. Fittings 4" and larger shall be cement lined and seal coated in accordance with ANSI/AWWA standard C104/A21.4 latest revision. Water Main fitting shall be colored blue in accordance with Florida state statutes.

30.7. Cast iron and ductile iron fittings for sewage force mains shall conform to ANSI/AWWA standard C110/A21.10 latest revision. Fittings 4" and larger shall be coated in accordance with the requirements of ductile iron pipe for sewage force mains.

30.8. Joints for bell and spigot ductile iron pipe and fittings shall conform to ANSI/AWWA standard C111/A21.11 latest revision. Mechanical joint or push-on joint to be rubber gasket compression-type. Special fittings and joints shall be considered for specific installation subject to the approval of the engineer.

30.9. Joints for PVC pressure pipe shall be bell and spigot push-on rubber gasket type only. No solvent weld or threaded joints will be permitted.

30.10. Water distribution system restraint: all fittings and specific pipe joints shall be restrained as outlined below:

- Joint restraint
- Push-on P.V.C. EBAA iron series 1600
- Push-on DIP EBAA iron series 1700
- tr-flex by U.S. Pipe or
- flex ring by American
- Fittings w/ DIP EBAA iron series 1100 megalug
- Fittings w/ P.V.C. EBAA iron series 2000 megalug
- Length of restrained pipe shall be as indicated on restrained joint pipe detail. (see water & sewer detail sheet)

30.11. Sewage force main system restraint: all fittings and specific pipe joints shall be restrained as outlined below

- Joint restraint
- Push-on P.V.C. EBAA iron series 1600
- Push-on DIP EBAA iron series 1700
- tr-flex by U.S. Pipe or
- flex ring by American
- Fittings w/ DIP EBAA iron series 1100 megalug
- Fittings w/ P.V.C. EBAA iron series 2000 megalug
- Length of restrained pipe shall be as indicated on restrained joint pipe detail. (see water & sewer detail sheet)

30.12. Water distribution valves shall be gate valves, iron body, fully resilient seat bronzed mounted non-rising stem, rated at 200 PSI and conforming to ANSI/AWWA C509 latest revision, and shall have mechanical joints.

30.12.1. Gate valves 4" and larger shall be Mueller A-2360, American 250 line or Clow F-6100, conforming to ANSI/AWWA C500 latest revision or approved equal.

30.12.2. Tapping valves shall be Mueller T-2360 or approved equal.

30.12.3. Gate valves 3" or less shall be Nibco T-133 or T-136 with malleable hand wheels or approved equal.

30.13. Tapping sleeves shall be Mueller H615, Clow F- 2505 or approved equal.

30.14. Valve boxes shall be U.S. foundry 7630 or approved equal painted blue with the designation "water".

30.15. Retainer glands for DIP shall conform to ANSI/AWWA C111/A21.11 latest revision. All glands shall be manufactured from ductile iron as listed by underwriters laboratories for 250 psi minimum water pressure rating. Clow corporation model F-1058, standard fire protection equipment company or approved equal.

30.16. Dresser couplings shall be regular black couplings with plain gaskets for galvanized steel pipe. They shall be dresser style 90. No substitutions allowed.

30.17. Fire hydrants shall be Mueller centurion traffic type A-423 with 5 1/4" internal valve opening or approved equal. Pumper nozzle to be 18" from

finished grade. All hydrants to be installed with control valve. Retainer glands are preferred for restraining. Fire hydrant shall comply with ANSI/AWWA C502 latest revision. Fire hydrants shall be painted in accordance with NFPA #291 or per agency standards having jurisdiction. Blue raised reflective pavement marker (rpm) shall be used to identify fire hydrant location. The placement of the rpm to be at the centerline of the outside roadway lane.

30.18. Sewage force main valves shall be plug valves which shall be of the non-lubricated, eccentric type with resilient faced plugs, port areas for valves 20 inches and smaller shall be at least 80% of full pipe area. Port area of valves 24 inches and larger shall be at least 70% of full pipe area. The body shall be of semi-steel (ASTM A-126 C1.b) and shall have bolted bonnet which gives access to the internals of the valve. Seats shall be welded overlay of high nickel content or a stainless steel plate locked in the body cavity. If a plate is used, it shall be replaceable through the bonnet access. Bearings shall be permanently lubricated of stainless steel, bronze or Teflon lined, fiber glass backed Duralon. Bearing areas shall be isolated from the flow with grit seals. Valves shall have packing bonnets where the shaft protrudes from the valve and the packing shall be self-adjusting chevron type which can be replaced without removing the bonnet. All nuts, bolts, springs and washers shall be stainless steel.

30.19. Plug valves shall be designed for a working pressure of 150 PSI the valve and actuator shall be capable of satisfactory operation in either direction of flow against pressure drops up to and including 100 PSI (for plug valves over 12" in diameter). Valves shall be bubble tight in both directions at 100 psi differential. Plug valves over 12" in diameter shall have worm gear operators. The operating mechanism shall be for buried service with a 2 inch square operating nut.

30.20. Plug valves are to be installed with the seat pointed towards the upstream flow, when specified.

30.21. Swing check valves for water, sewage, sludge, and general service shall be of the outside lever and spring or weight type, in accordance with ANSI/AWWA C 508 latest revision swing-check valves for waterworks service, 2" through 24" NPS, unless otherwise indicated, with full-opening passages, designed for a water-working pressure of 150 PSI they shall have a flanged cover piece to provide access to the disc.

30.22. High density polyethylene pipe (HDPE) for water distribution mains shall conform to AWWA C906 standard, latest revision. Pipes shall be color-coded blue, minimum 40 feet standard lengths.

31. Service connection:

31.1. Service saddles shall be fusion bonded plastic coated ductile iron (ASTM A536) with stainless steel straps, saddles shall be double strap type.

31.2. Service lines shall be polyethylene (PE 3408), 200 p.s.i rated, DR9. Pipe joints shall be of the compression type totally confined grip seal and coupling nut.

31.3. Corporation stops shall be manufactured of brass alloy in accordance with ASTM B-62 with threaded ends, as manufactured by Ford ballcorp, catalog # 1100 or approved equal.

31.4. Curb stops shall be Ford v63-44w-x" latest revision or approved equal.

31.5. Meter stops shall be 90 degree lockwing type and shall be of bronze construction in accordance FV63-777W" latest revision with ASTM B-62. Meter stops shall be closed bottom design and resilient "O" ring sealed against external leakage at the top. Stops shall be equipped with a meter coupling nut on the outlet sides, as manufactured by Ford or approved equal.

32. Installation:

32.1. Where restrained pipe joints are required due to fittings, appurtenances, etc., pipe material shall be DIP

32.2. All PVC pipe shall be installed in accordance with the uni-bell plastic pipe association "guide for installation of PVC pressure pipe for municipal water distribution system," and ANSI/AWWA C605-xx latest revision standard.

32.3. All DIP shall be installed in accordance with ANSI/ C600-xx latest revision.

32.4. All water mains shall typically be laid with a minimum 36" cover for PVC and 30" cover for DIP.

32.5. Detector tape shall be laid 18 inches above all water and sewer lines. A 14 gauge multi-strand wire shall be attached to all nonconductive water mains to facilitate location. An extra 4 feet of wire shall be provided at all valves, blow-offs, hydrants, etc. The wire shall be tested for continuity at the pressure test.

32.6. Pipe deflection shall not exceed 50% of the maximum deflection recommended by the manufacturer.

32.7. A continuous and uniform bedding shall be provided. Backfill material shall be placed in accordance with the plans and specifications.

32.8. All valves shall be installed with adjustable cast iron valve boxes with the word "water" or "sewer", as applicable, in the cover. U.S. foundry or approved equal.

33. Testing:

33.1. Before any physical connections and acceptance for operation to the existing water mains are made, the complete water system shall be flushed, pressure tested and disinfected. Copies of passing bacteriological results and pressure test results must be submitted to, and approved by, the engineer, utility owner, and health department. Hydrostatic testing of new mains shall be performed at a minimum starting pressure of 150 PSI for two hours in accordance with ANSI/AWWA C600-05 (hydrostatic test). The pressure test shall not vary more than 5 PSI during the test. The allowable leakage during the pressure test shall be less than the number of gallons per hour as determined by the formula:

L = (sd(p)1/2)/148,000.

In which L equals the allowable leakage in gallons per hour. S equals length of pipe (linear feet), d equals nominal diameter of pipe (inches) and p equals the average test pressure (pounds per square inch gauge). Maximum length of test pipe section should be 2000 feet. The water system shall be disinfected in accordance with the ANSI/AWWA C651-05 (water main bacteriological tests).

33.2. The pressure test shall be witnessed by a representative of the utility owner and the engineer of record.

33.3. For water distribution pipes, sampling points shall be provided by the contractor at the locations shown on the plans.

33.4. For water distribution pipes, disinfection and bacteriological testing shall be in accordance with ANSI/AWWA C651-14 (water main bacteriological tests). Maximum distance between sampling points shall be as follows:

- Transmission mains: every 1200 feet
- Branch mains: every 1000 feet
- Isolated mains < 1000 feet: 2 sample points
- Isolated mains > 1000 feet: 3 sample points

Section 40 - Gravity Sanitary Sewer Collection System

40. General:

40.1. Manhole, valve box, meter box and other structure rim elevations within the limits of construction are to be adjusted to conform to plan grades proposed in these plans. If no other individual cost item is included in the contract schedule for a particular structure adjustment.

40.2. Distance and lengths shown on plans and profile drawings are referenced to the center of structures.

41. Materials:

Note: If materials list here on are in conflict with utility owner, material owner requirements shall govern.

41.1. All PVC sewer pipe and fittings shall be non-pressure polyvinyl chloride (PVC) pipe conforming to ASTM D 3034, SDR 26, with push-on rubber gasket joints.

41.2. Ductile iron pipe shall conform to ANSI/AWWA C151/A21.51-xx latest revision, "ductile iron pipe centrifugally cast in metal molds or sand-lined molds" with wall thickness class 51 for 8" and above, class 52 for 4" and 6", unless otherwise directed by the engineer. Ductile iron pipe shall be epoxy lined or coated with the manufacturer's coating system as approved by the engineer of record and the local municipality or utility owner. In either case, the engineer's review and approval is required for either alternative prior to construction. Cement mortared linings are not appropriate for this application.

41.3. All ductile iron fittings shall conform to ANSI/AWWA standard C110/A21.10-xx latest revision. All fittings and accessories shall be epoxy lined and as manufactured or supplied by the pipe manufacturer or approved equal.

41.4. Manholes shall be precast per ASTM C 478 and in accordance with the plans and specifications.

41.5. Manholes are to be sealed with type II sulphate resistant cement or approved equal - no molding plaster.

41.6. Joints for bell and spigot ductile iron pipe and fittings shall conform to ANSI/AWWA standard C111/A21.11-xx latest revision. Mechanical joint or push-on joint to be rubber gasket compression- type.

41.7. PVC clean-outs to have screw type access plug. Long radius wye connections and fittings shall be used in order to access clean-out operations.

41.8. Cleanouts shall be installed at all sewer services exceeding 75' in length (every 75') with a clean out at the property line, easement line, or 5' from a building. The contractor shall coordinate the location of the building cleanout (5' from the building) and elevation of the end of the sewer service with the building plumbing contractor. Cleanouts shall be the same size as the service lateral in which they are installed.

42. Installation:

42.1. PVC sewer pipe shall be laid in accordance with ASTM D 2321 and the Uni-Bell plastic pipe association's "recommended practice for the installation of PVC sewer pipe."

42.2. DIP shall be installed in accordance with ANSI/AWWA C-600-xx latest revision.

42.3. Pipe to manhole connection to be Fernco neoprene boot couplings with stainless steel accessories or approved equal.

42.4. Manholes shall be set plumb to line and grade on firm subgrade providing uniform bearing under the base.

42.5. All openings and joints shall be sealed watertight.

42.6. Two coats of Koppers 300-m, first red, second one black, shall be applied to the inside of all manholes and shall be applied in accordance with the manufacturer's specifications (16 mils per coat). Coating as required by utility owner or engineer shall be applied to the outside of the manhole. The interior coats shall be applied after sewer lamping of lines. After the application of each coat, the utility owner and engineer shall inspect the manholes. The inspection shall be scheduled a minimum of 48 hours prior to inspection.

43. Testing: Testing of gravity sewer mains and laterals shall be in accordance with the utility owner's minimum design and construction standards latest revision.

43.1. After construction of the sewer system, the engineer may require a visual infiltration and/or exfiltration test to be performed on the entire system or any part thereof.

43.2. An air test may be substituted for the water exfiltration test, upon approval of the engineer.

43.3. The allowable limits of sewer pipe leakage for gravity sewer mains shall not exceed 100 gallons per inch of inside pipe diameter per mile per day for any section tested. No visible leakage shall be allowed.

43.4. The installed sewers may require video inspections.

LEDER HILLSBORO STORAGE

SCALE: AS NOTED

DATE ISSUED: JANUARY 31, 2018

DRAWN BY: MG

DESIGNED BY: MG

CHECKED BY: SW

STEPHEN D. WILLIAMS, P.E.
FLORIDA REG. NO. 32090
(FOR THE FIRM)

SHEET TITLE

 
 
CONSTRUCTION SPECIFICATIONS

SHEET NUMBER

GI-002

SHEET 02 of 27

PROJECT NO. 09675.00



BID / CONTRACT NO. :

REVISIONS

NO.	DESCRIPTION	DATE
1	PER DRC COMMENTS	6/8/201
2	PER DRC COMMENTS	8/24/17

LEDER
HILLSBORO
STORAGE

SCALE: AS NOTED

DATE ISSUED: JANUARY 31, 2018

DRAWN BY: MG

DESIGNED BY: MG

CHECKED BY: SW

STEPHEN D. WILLIAMS, P.E.
FLORIDA REG. NO. 32090
(FOR THE FIRM)

SHEET TITLE	PROJECT TITLE
STORM WATER	PROJECT NO.
POLLUTION	DATE
PREVENTION PLAN	DRAWN BY


SHEET NUMBER

CG-101

SHEET 04 of 27

PROJECT NO. 09675.00


MATCH LINE-SEE SHEET CG-102

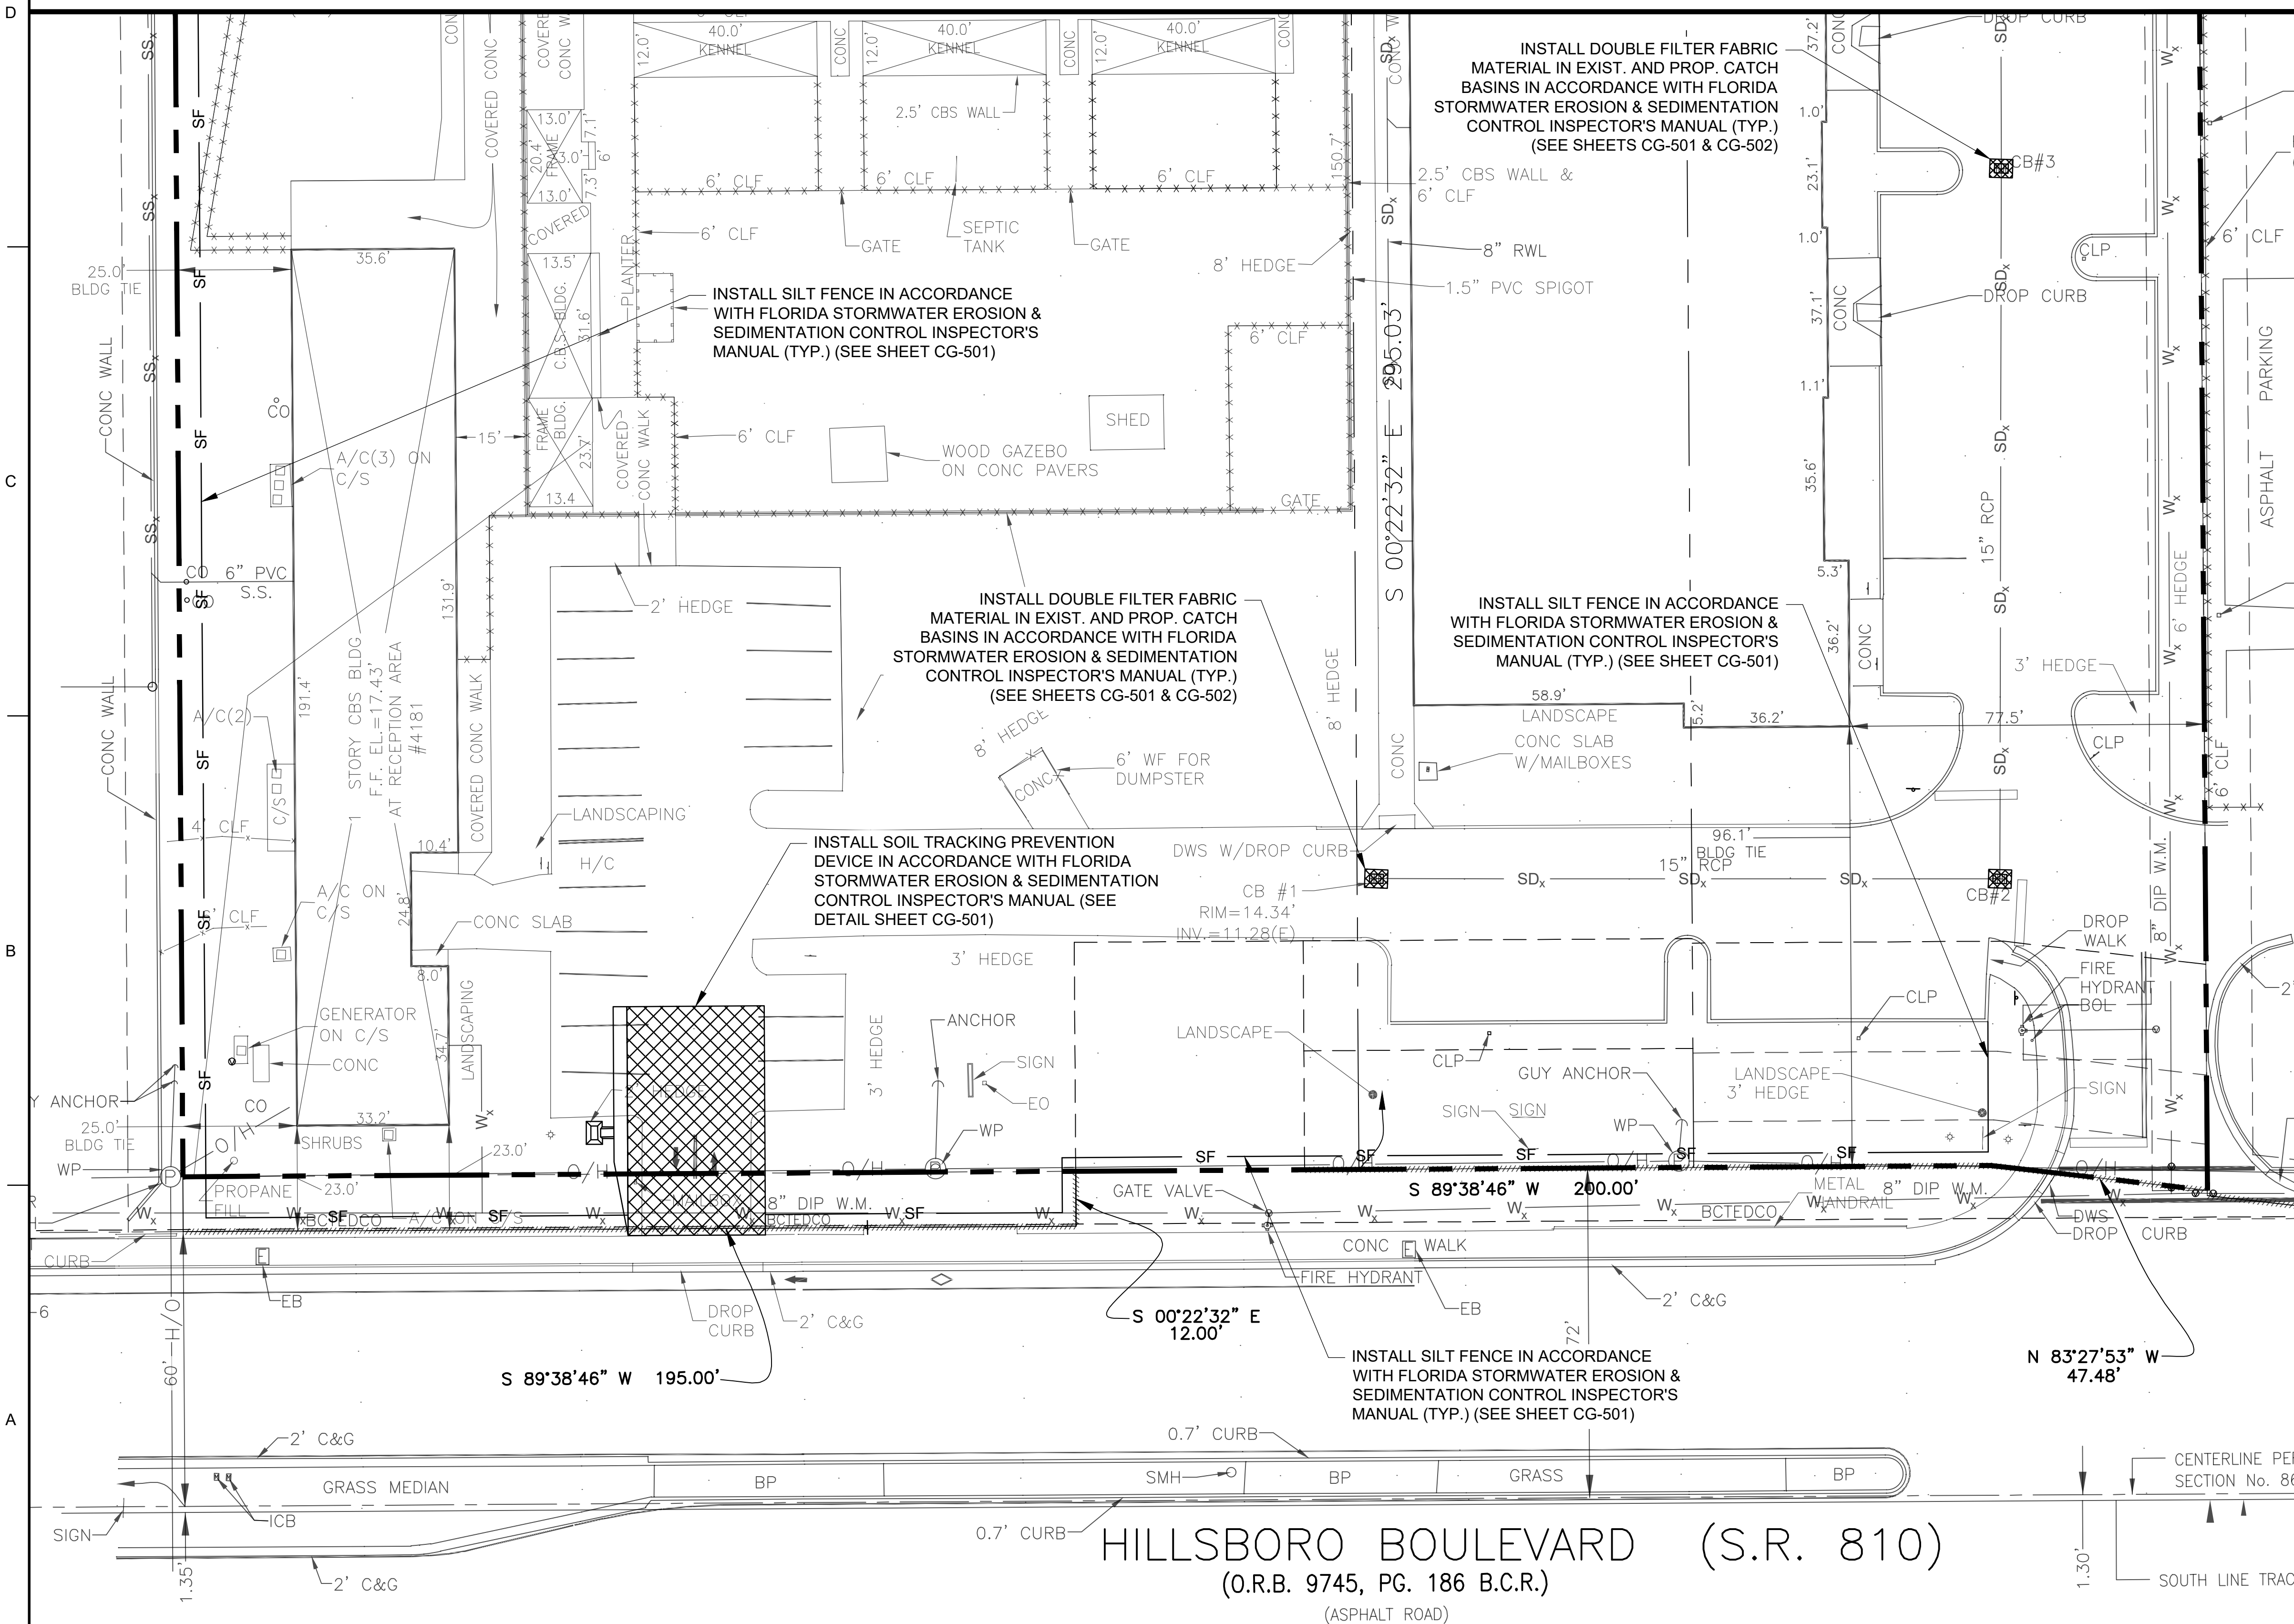

HILLSBORO BOULEVARD (S.R. 810)

(O.R.B. 9745, PG. 186 B.C.R.)

(ASPHALT ROAD)

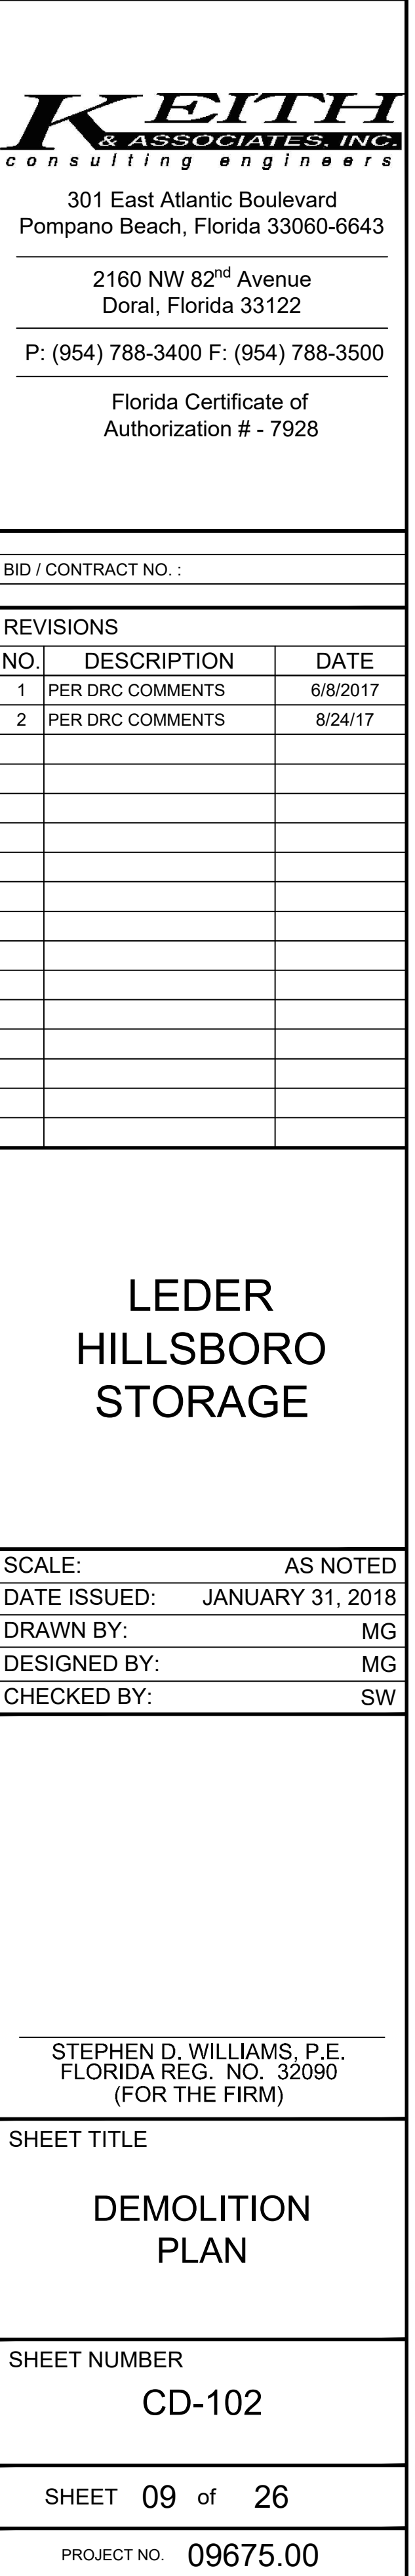

Florida Certificate of
Authorization # - 7928

NO.	DESCRIPTION	DATE
1	PER DRC COMMENTS	6/8/2017
2	PER DRC COMMENTS	8/24/17

LEDER HILLSBORO STORAGE					
SCALE:		AS NOTED			
DATE ISSUED:		JANUARY 31, 1988			
DRAWN BY:		MG			
DESIGNED BY:		MG			
CHECKED BY:		SW			

STEPHEN D. WILLIAMS, P.E.
FLORIDA REG. NO. 32090
(FOR THE FIRM)

SHEET TITLE

DEMOLITION
PLAN

SHEET NUMBER
CD-102

SHEET 09 of 26

PROJECT NO. 09675.00

- 9A CONST. 24" NYLOPLAST
HEAVY DUTY DRAIN
(OR APPROVED EQUAL)
BASIN W/ H-20 GRATE
GRATE EL.=14.07
INV. EL.=10.15 (N,E)
- 11A CONST. 24" NYLOPLAST
HEAVY DUTY DRAIN
(OR APPROVED EQUAL)
BASIN W/ H-20 GRATE
GRATE EL.=14.40
INV. EL.=10.15 (N,W)
- 11B CONST. 24" NYLOPLAST
HEAVY DUTY DRAIN
(OR APPROVED EQUAL)
BASIN W/ H-20 GRATE
GRATE EL.=14.47
INV. EL.=10.15 (N,E,W)

BROWARD COUNTY HIGHWAY CONSTRUCTION
AND ENGINEERING DIVISION

☐ PLAT CONSISTENT WITH PLAT REQUIREMENTS
PUBLIC R/W


☐ PUBLIC RIGHT OF WAY APPROVAL FOR
PAVING, GRADING AND DRAINAGE

BY: _____ DATE: _____

DOES NOT INCLUDE APPROVAL OF PAVEMENT MARKINGS & SIGNS

THE PRESENCE OF GROUNDWATER SHOULD BE
ANTICIPATED. CONTRACTOR'S BID SHALL
INCLUDE CONSIDERATION FOR ADDRESSING THIS
ISSUE AND OBTAINING ALL NECESSARY PERMITS.

NOTE: PRINTED DRAWING SIZE MAY
HAVE CHANGED FROM ORIGINAL. VERIFY
SCALE USING BAR SCALE ABOVE.

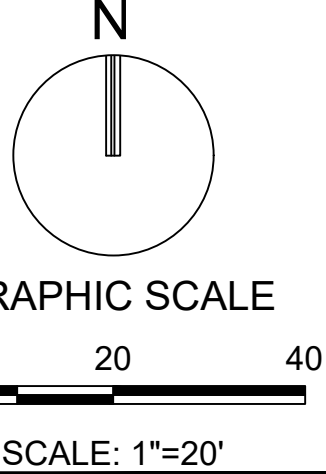

KEITH

Corporate Office
301 East Atlantic Boulevard
Pompano Beach, Florida 33060-6643
(954) 788-3400


Miami-Dade County
2160 NW 82 Avenue
Doral, Florida 33122

Palm Beach County
120 N Federal Highway, Suite 208
Lake Worth, Florida 33460

Orange County
2948 E Livingston Street
Orlando, Florida 32803

State of Florida Certificate of
Authorization Number - 7928

MATCH LINE-SEE SHEET CP-102

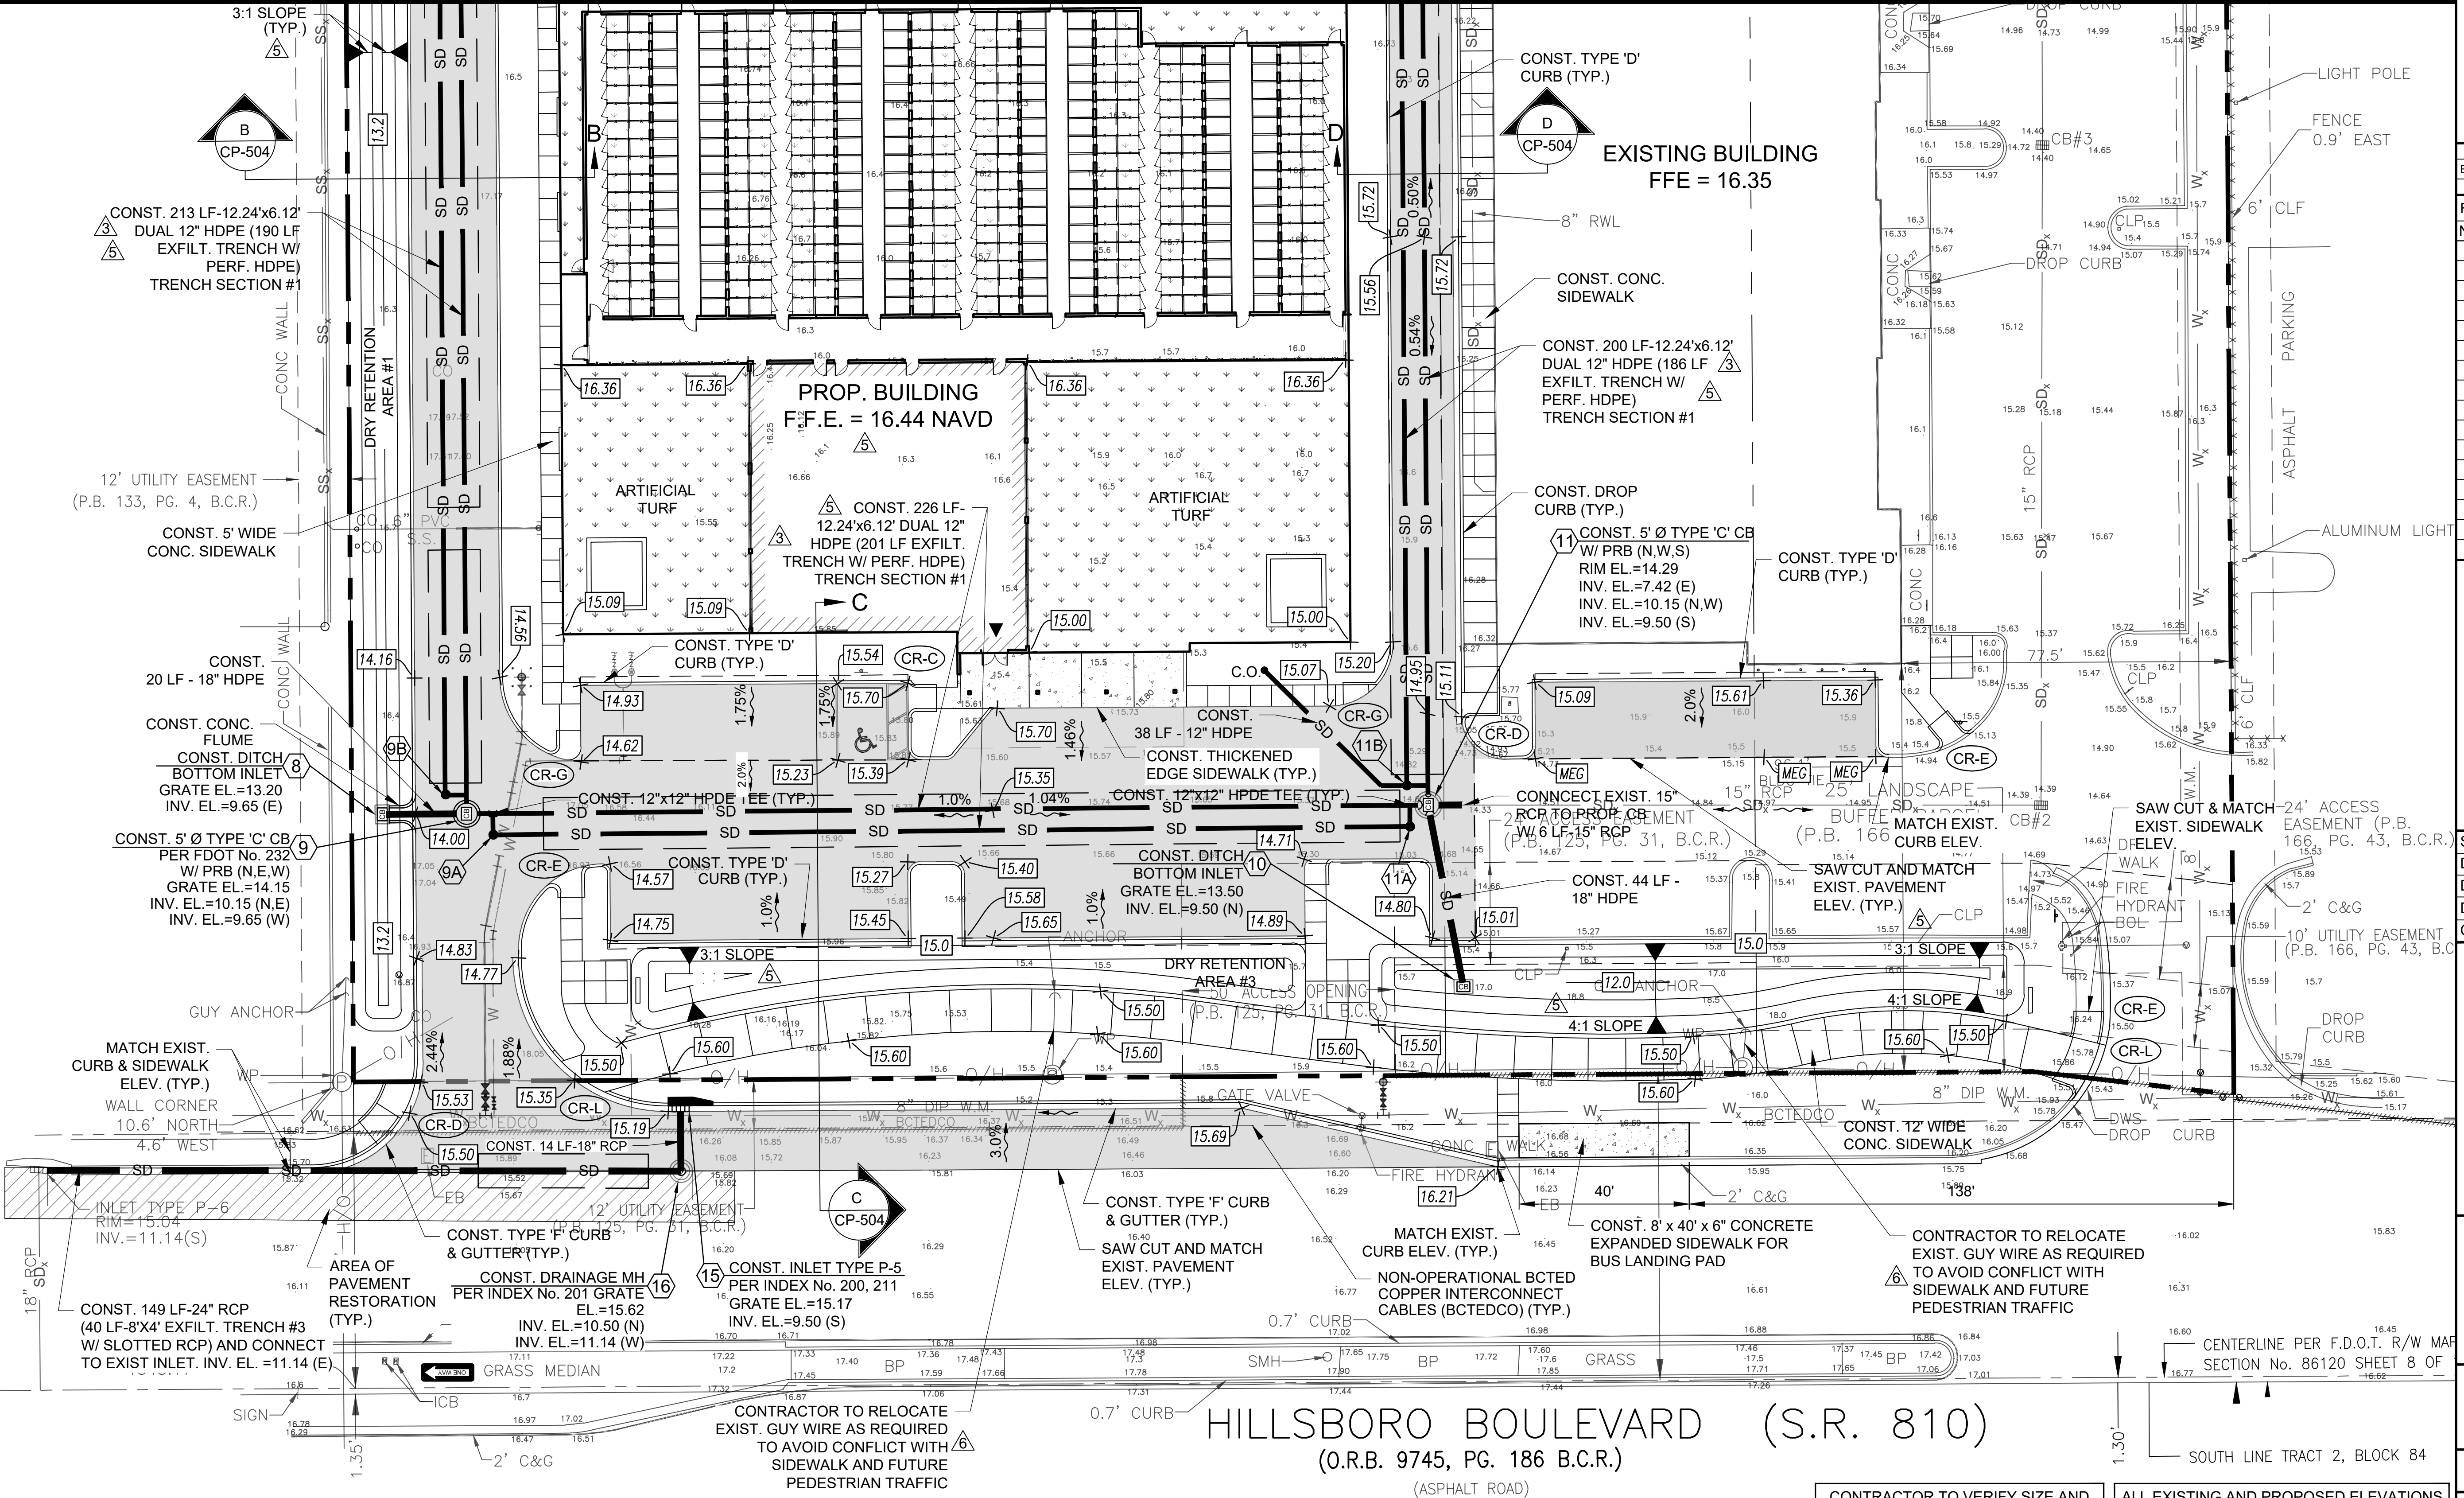

BID / CONTRACT NO. :

REVISIONS		
NO.	DESCRIPTION	DATE
1	PER DRC COMMENTS	6/8/2017
2	PER DRC COMMENTS	8/24/17
3	PER BCEPGMD COMMENTS	12/12/2017
4	PER CITY COMMENTS	12/28/2017
5	PER BCEPGMD COMMENTS	3/29/18
6	PER BCHCED COMMENTS	6/15/18

**LEDER
HILLSBORO
STORAGE**

SCALE: AS NOTED
DATE ISSUED: JANUARY 31, 2018
DRAWN BY: MG
DESIGNED BY: MG
CHECKED BY: SW

STEPHEN D. WILLIAMS, P.E.
FLORIDA REG. NO. 32090
(FOR THE FIRM)

**PAVING, GRADING
AND DRAINAGE PLAN**

SHEET NUMBER
CP-101

SHEET 10 of 27


PROJECT NO. 09675.00

HILLSBORO BOULEVARD (S.R. 810)
(O.R.B. 9745, PG. 186 B.C.R.)
(ASPHALT ROAD)

CONTRACTOR TO VERIFY SIZE AND
LOCATION OF ALL EXISTING UTILITIES

ALL EXISTING AND PROPOSED ELEVATIONS
SHOWN ARE BASED ON NAVD 1988

Drawing name: A:\090975.00 - Hill Lodge - Leder Group\Engineering\Drawings\CP-CP-101.dwg Plotted on: Jun 20, 2018 1:03pm Plotted by: MCDink

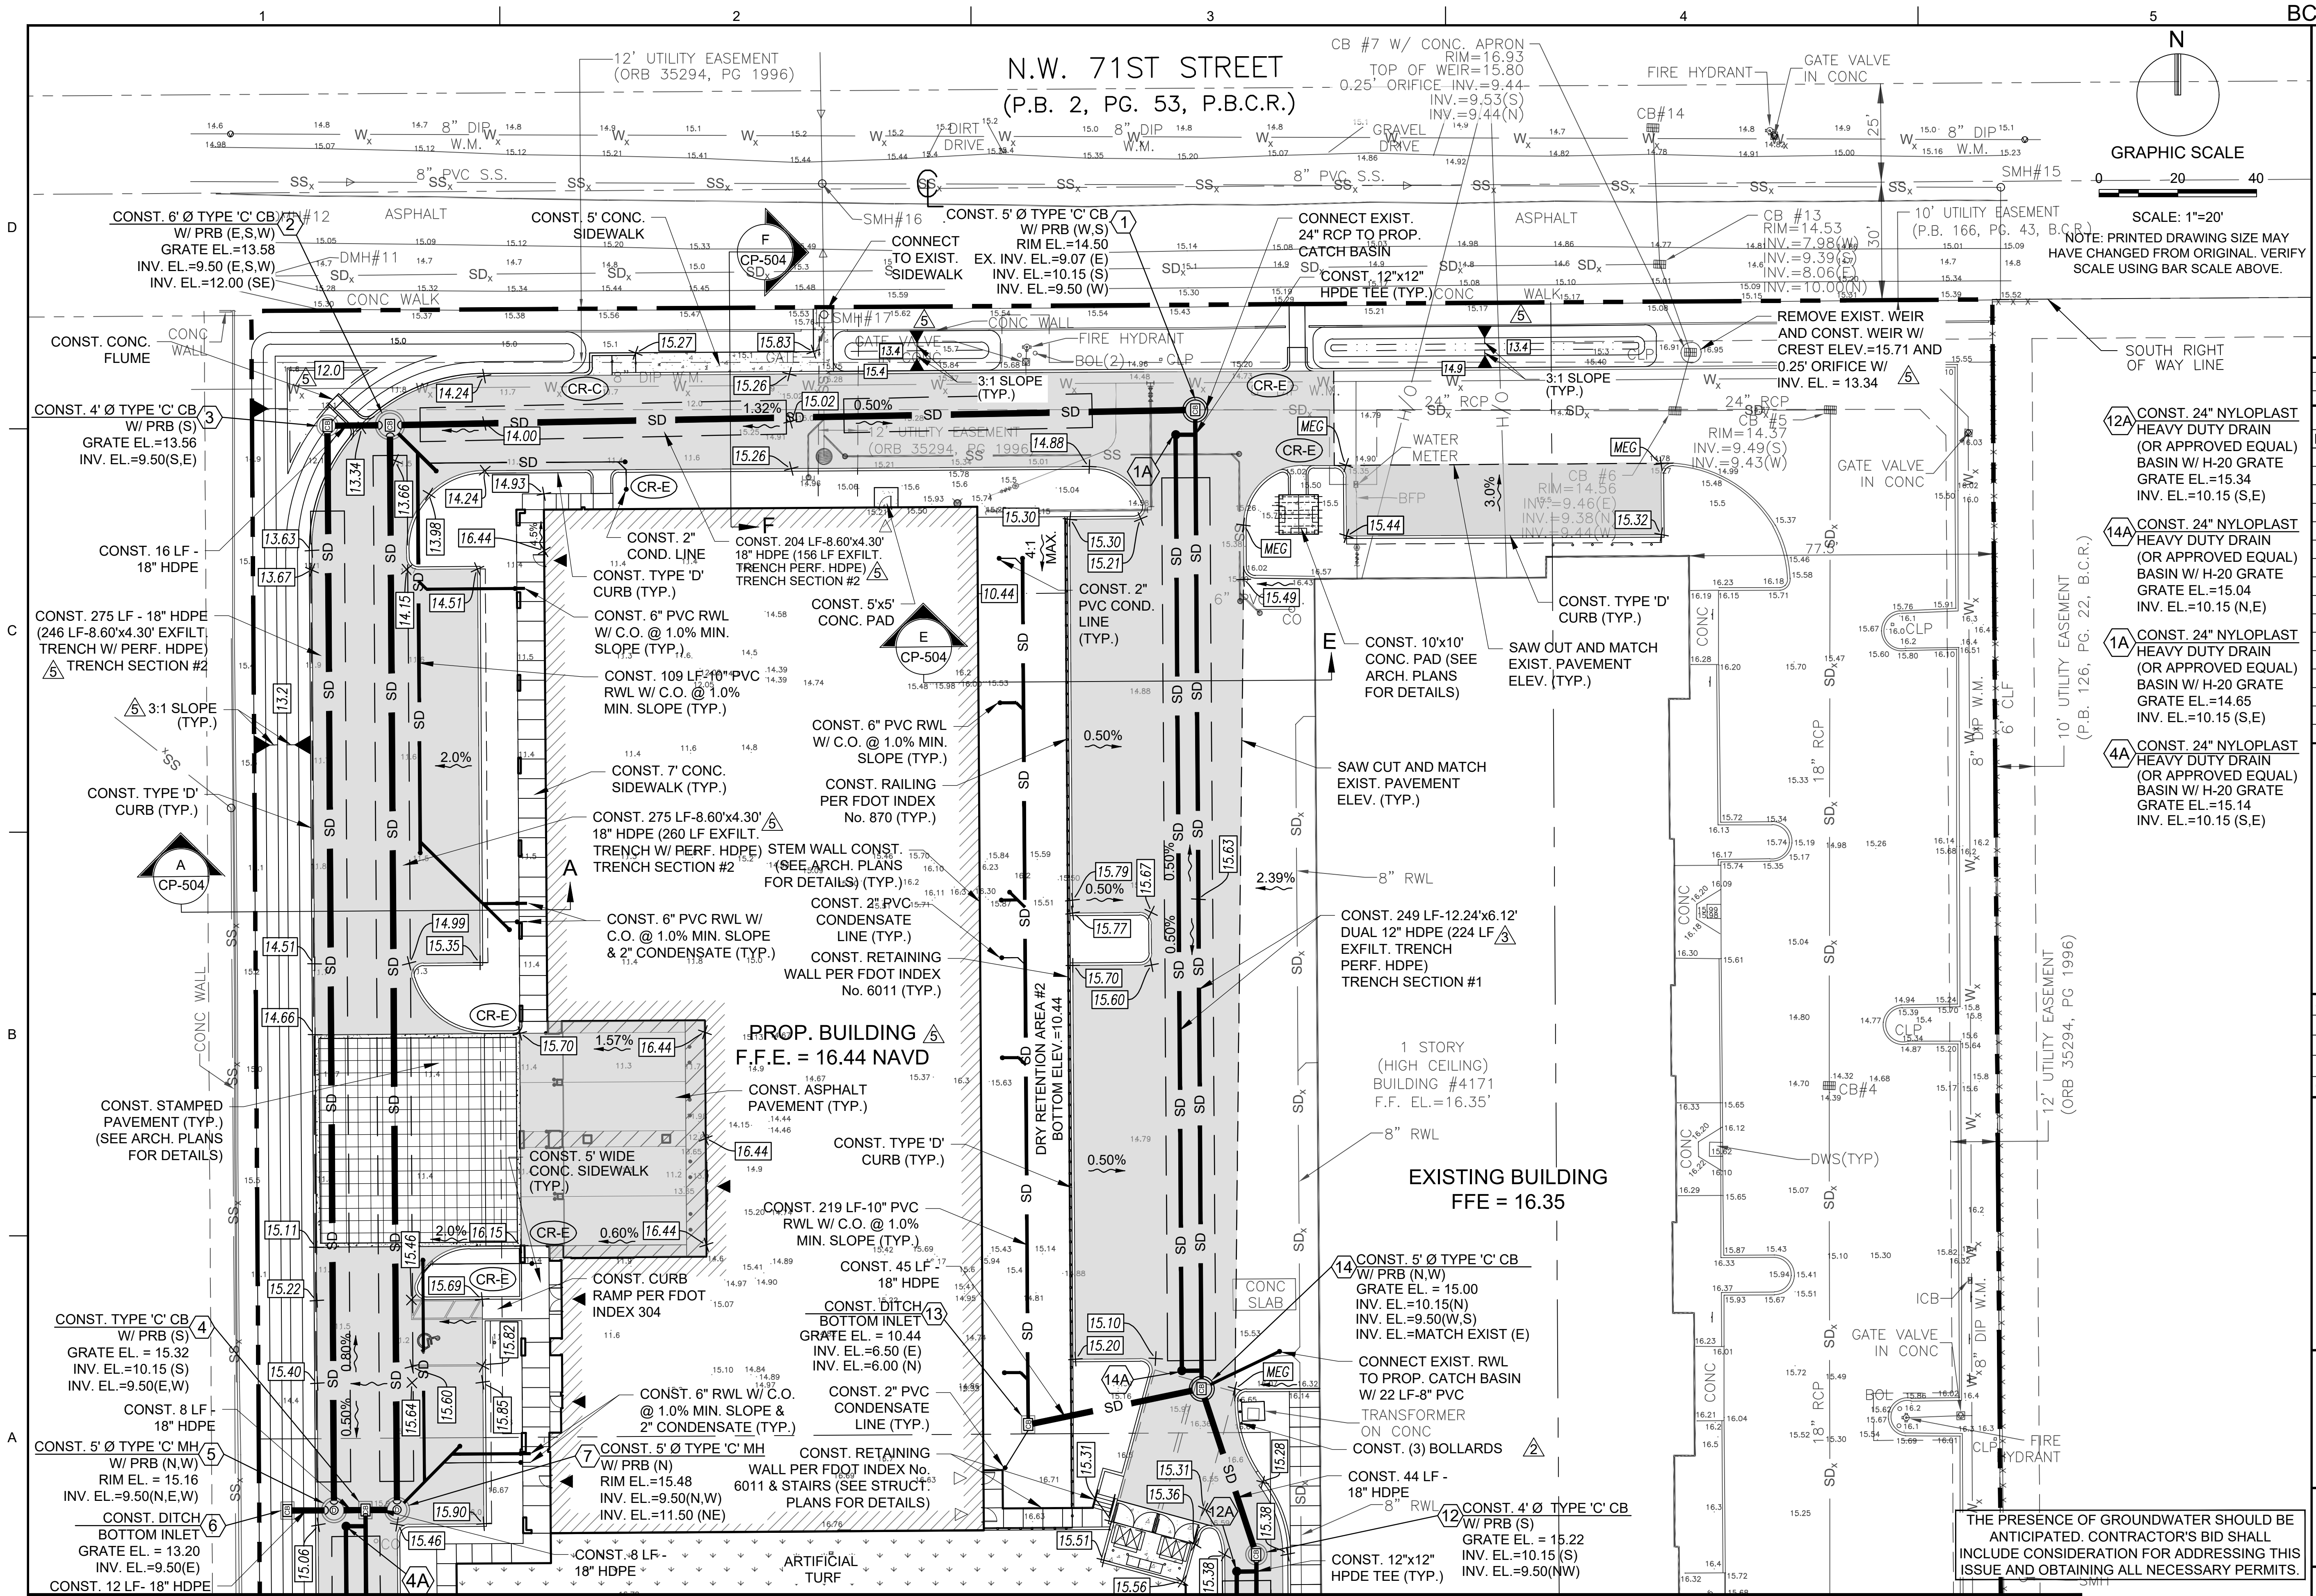

THE PRESENCE OF GROUNDWATER SHOULD BE ANTICIPATED. CONTRACTOR'S BID SHALL INCLUDE CONSIDERATION FOR ADDRESSING THIS ISSUE AND OBTAINING ALL NECESSARY PERMITS.

CONTRACTOR TO VERIFY SIZE AND
LOCATION OF ALL EXISTING UTILITIES

ALL EXISTING AND PROPOSED ELEVATIONS
SHOWN ARE BASED ON NAVD 1988

MATCH LINE-SEE SHEET CP-101

Miami-Dade County
2160 NW 82 Avenue
Doral, Florida 33122

Orange County
48 E Livingston Street
Orlando, Florida 32803

State of Florida Certificate of
Authorization Number - 7928

REVISIONS


[illegible]

SCALE:	AS NOTED
DATE ISSUED:	JANUARY 31, 2018
DRAWN BY:	MG
DESIGNED BY:	MG
CHECKED BY:	SW

DESIGNED BY:	MS
CHECKED BY:	SW

STEPHEN D. WILLIAMS, P.E.
FLORIDA REG. NO. 32090
(FOR THE FIRM)

PROJECT NO. 09675.00

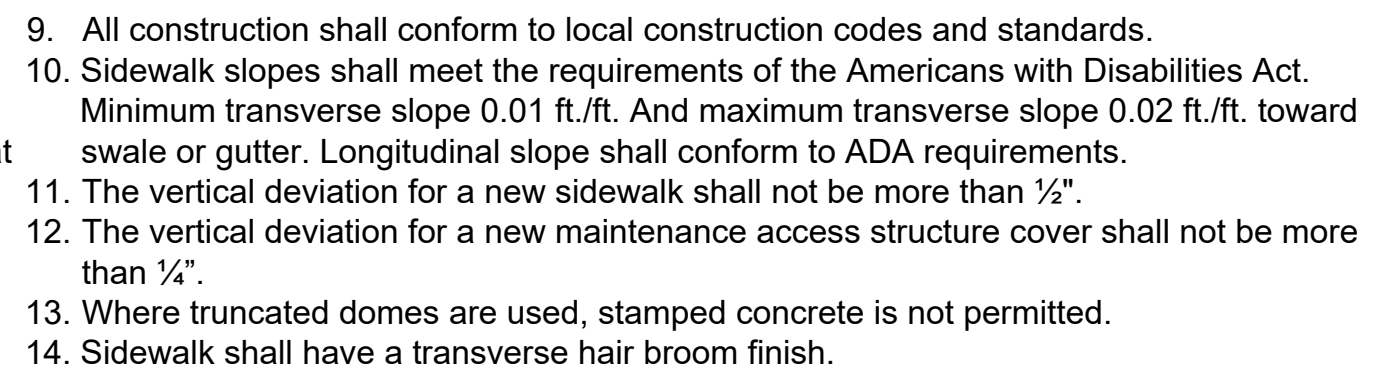

9. All construction shall conform to local construction codes and standards.
10. Sidewalk slopes shall meet the requirements of the Americans with Disabilities Act. Minimum transverse slope 0.01 ft./ft. And maximum transverse slope 0.02 ft./ft. toward swale or gutter. Longitudinal slope shall conform to ADA requirements.
11. The vertical deviation for a new sidewalk shall not be more than 1/4".
12. The vertical deviation for a new maintenance access structure cover shall not be more than 1/4".
13. Where truncated domes are used, stamped concrete is not permitted.
14. Sidewalk shall have a transverse hair broom finish.



Corporate Office
301 East Atlantic Boulevard
Pompano Beach, Florida 33060-6643
(954) 788-3400

Miami-Dade County
2160 NW 82 Avenue
Doral, Florida 33122

Palm Beach County
120 N Federal Highway, Suite 208
Lake Worth, Florida 33460

Orange County
2948 E Livingston Street
Orlando, Florida 32803

State of Florida Certificate of
Authorization Number - 7928

BID / CONTRACT NO. :

REVISIONS

NO.	DESCRIPTION	DATE
1	PER DRC COMMENTS	6/8/2017
2	PER DRC COMMENTS	8/24/17
3	PER BCEPGMD COMMENTS	12/12/2017
4	PER BCEPGMD COMMENTS	6/15/2018

LEDER
HILLSBORO
STORAGE

SCALE: AS NOTED
DATE ISSUED: JANUARY 31, 2018
DRAWN BY: MG
DESIGNED BY: MG
CHECKED BY: SW





STEPHEN D. WILLIAMS, P.E.
FLORIDA REG. NO. 32090
(FOR THE FIRM)

SHEET TITLE
PAVING, GRADING
AND DRAINAGE
DETAILS

SHEET NUMBER
CP-502

SHEET 13 of 27

PROJECT NO. 09675.00

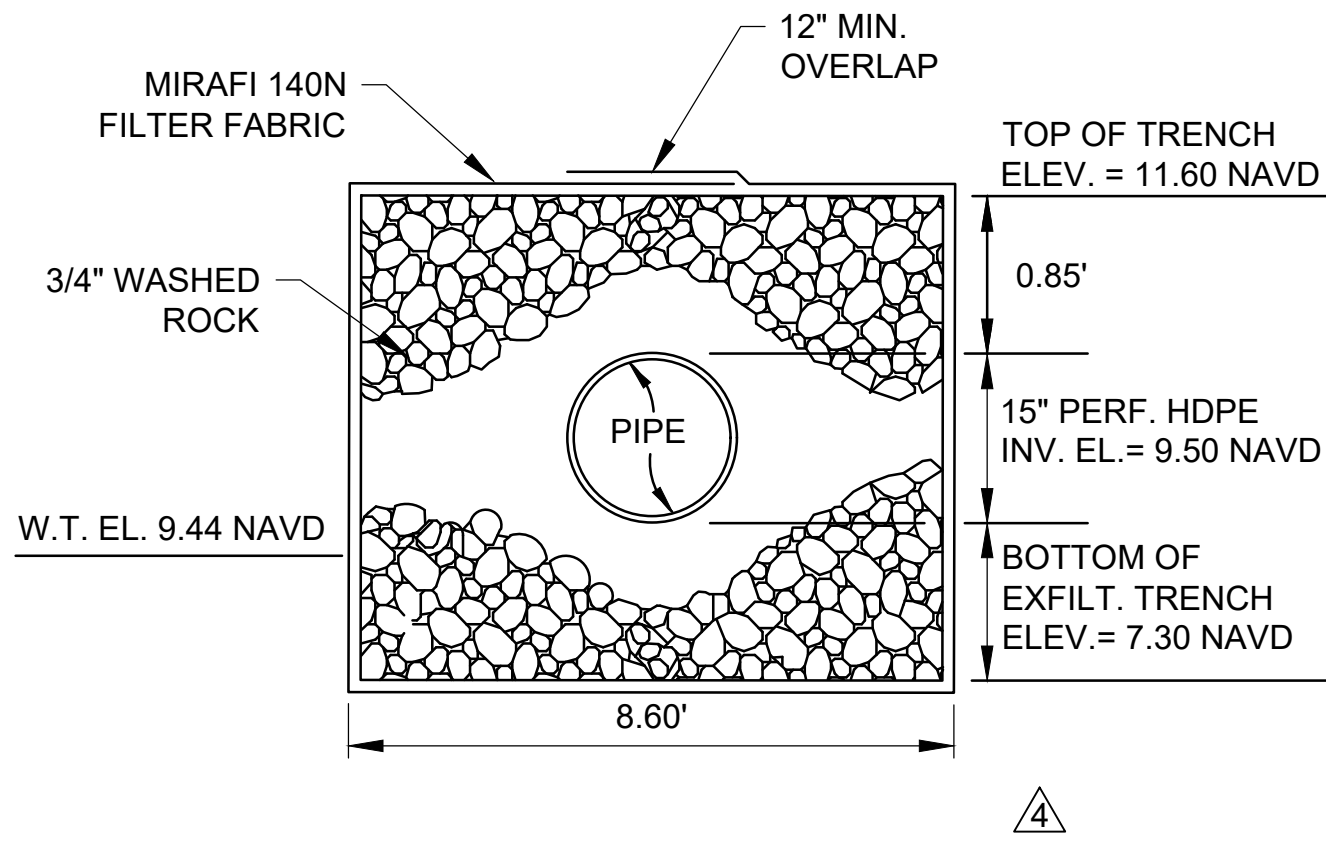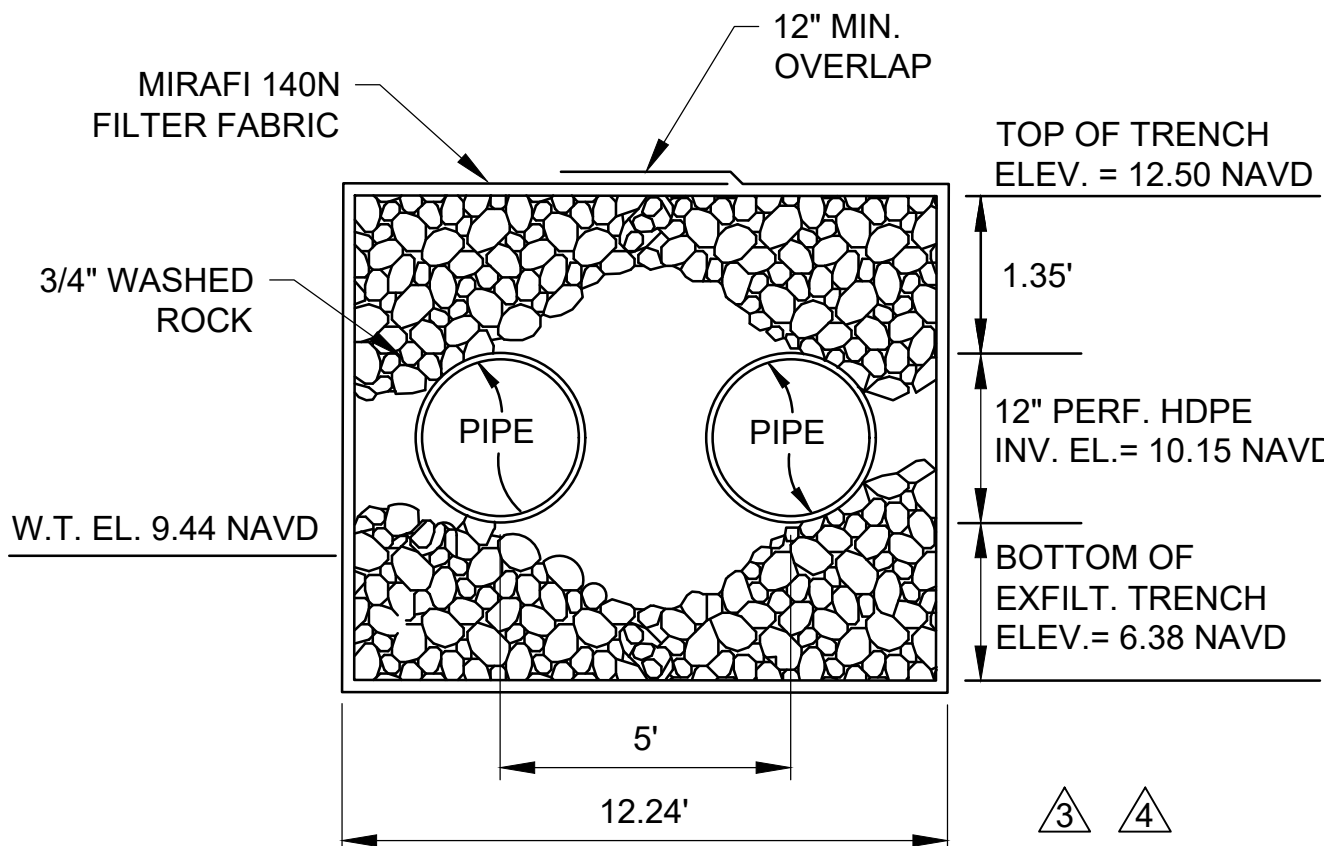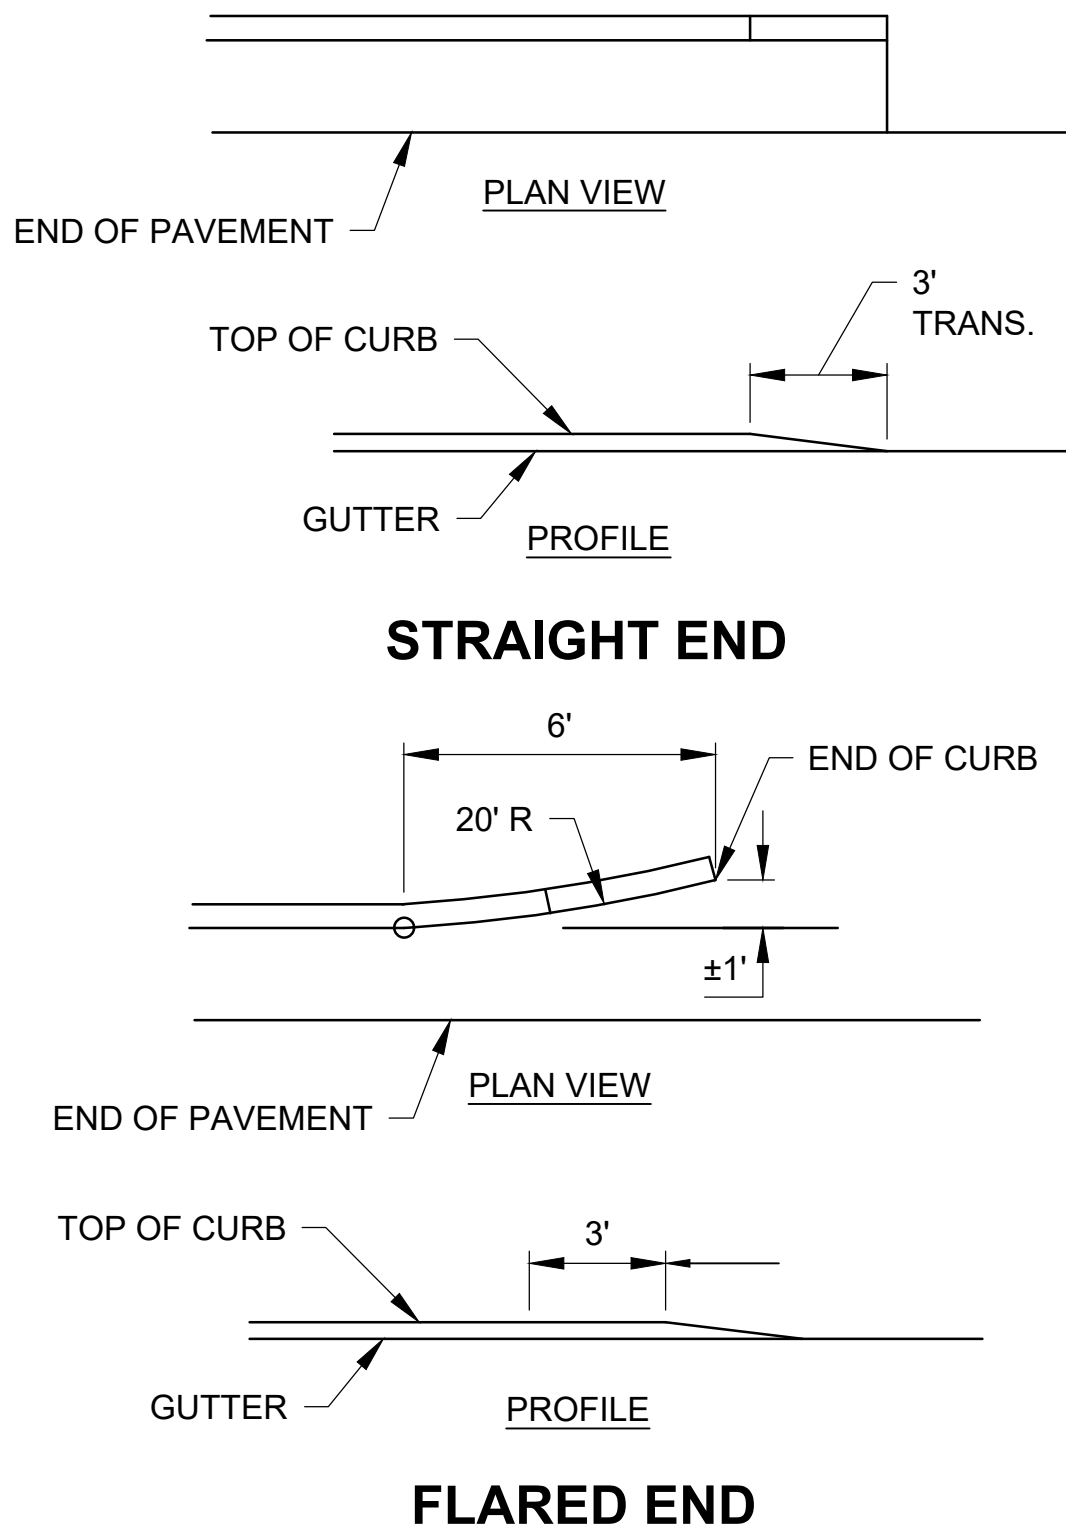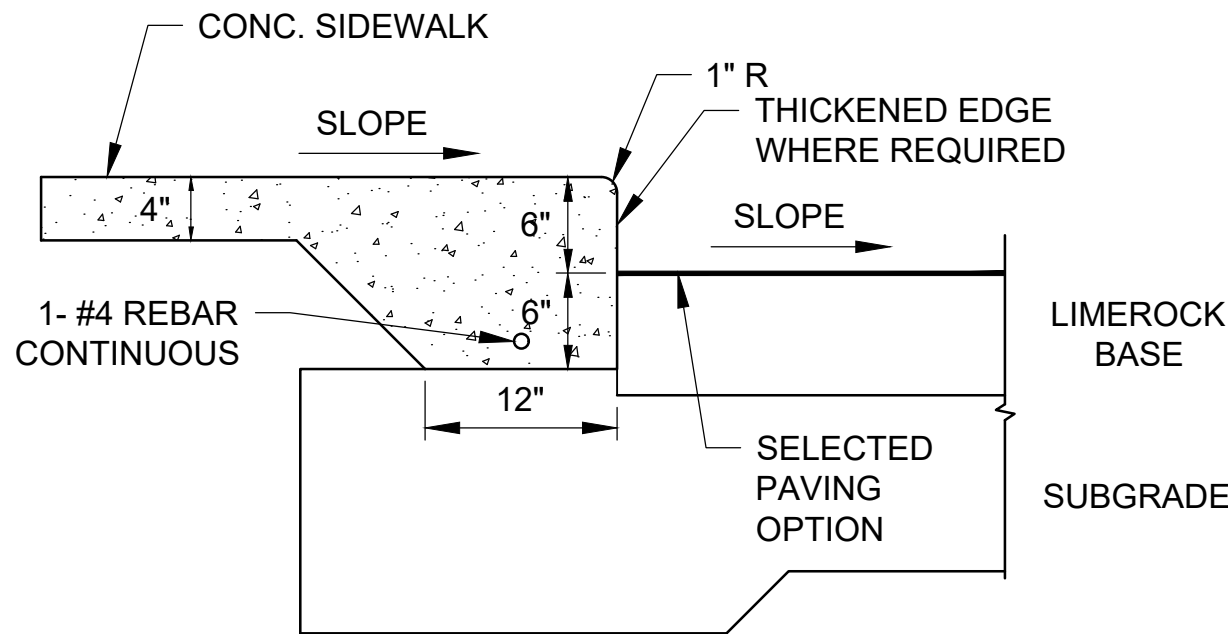

7B

THICKENED EDGE SIDEWALK

SCALE: NOT TO SCALE

8

CURB & GUTTER FLARED AND
STRAIGH ENDS

SCALE: NOT TO SCALE

11A


EXFILTRATION TRENCH DETAIL
SECTION #1

SCALE: NOT TO SCALE

11B

EXFILTRATION TRENCH DETAIL
SECTION #2


SCALE: NOT TO SCALE

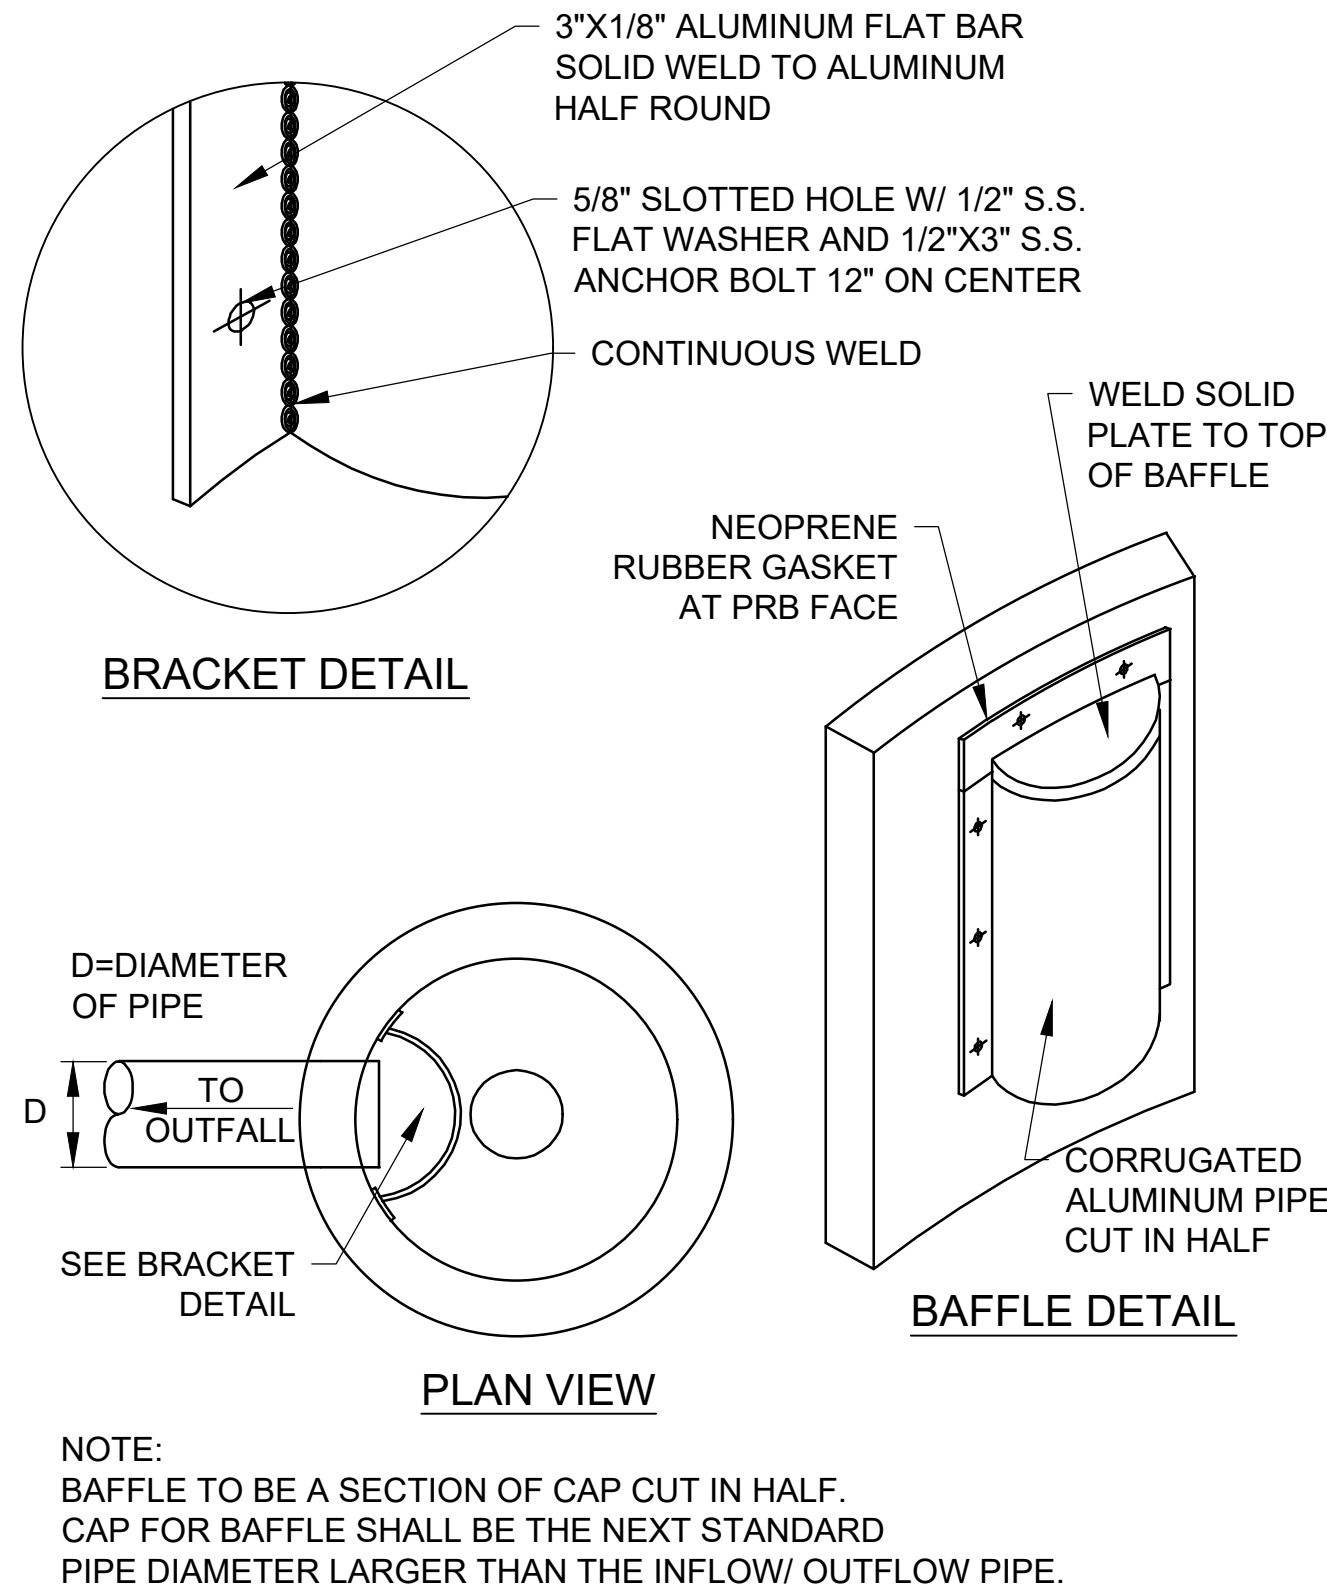

12

POLLUTION RETARDANT BAFFLE
DETAIL


SCALE: NOT TO SCALE

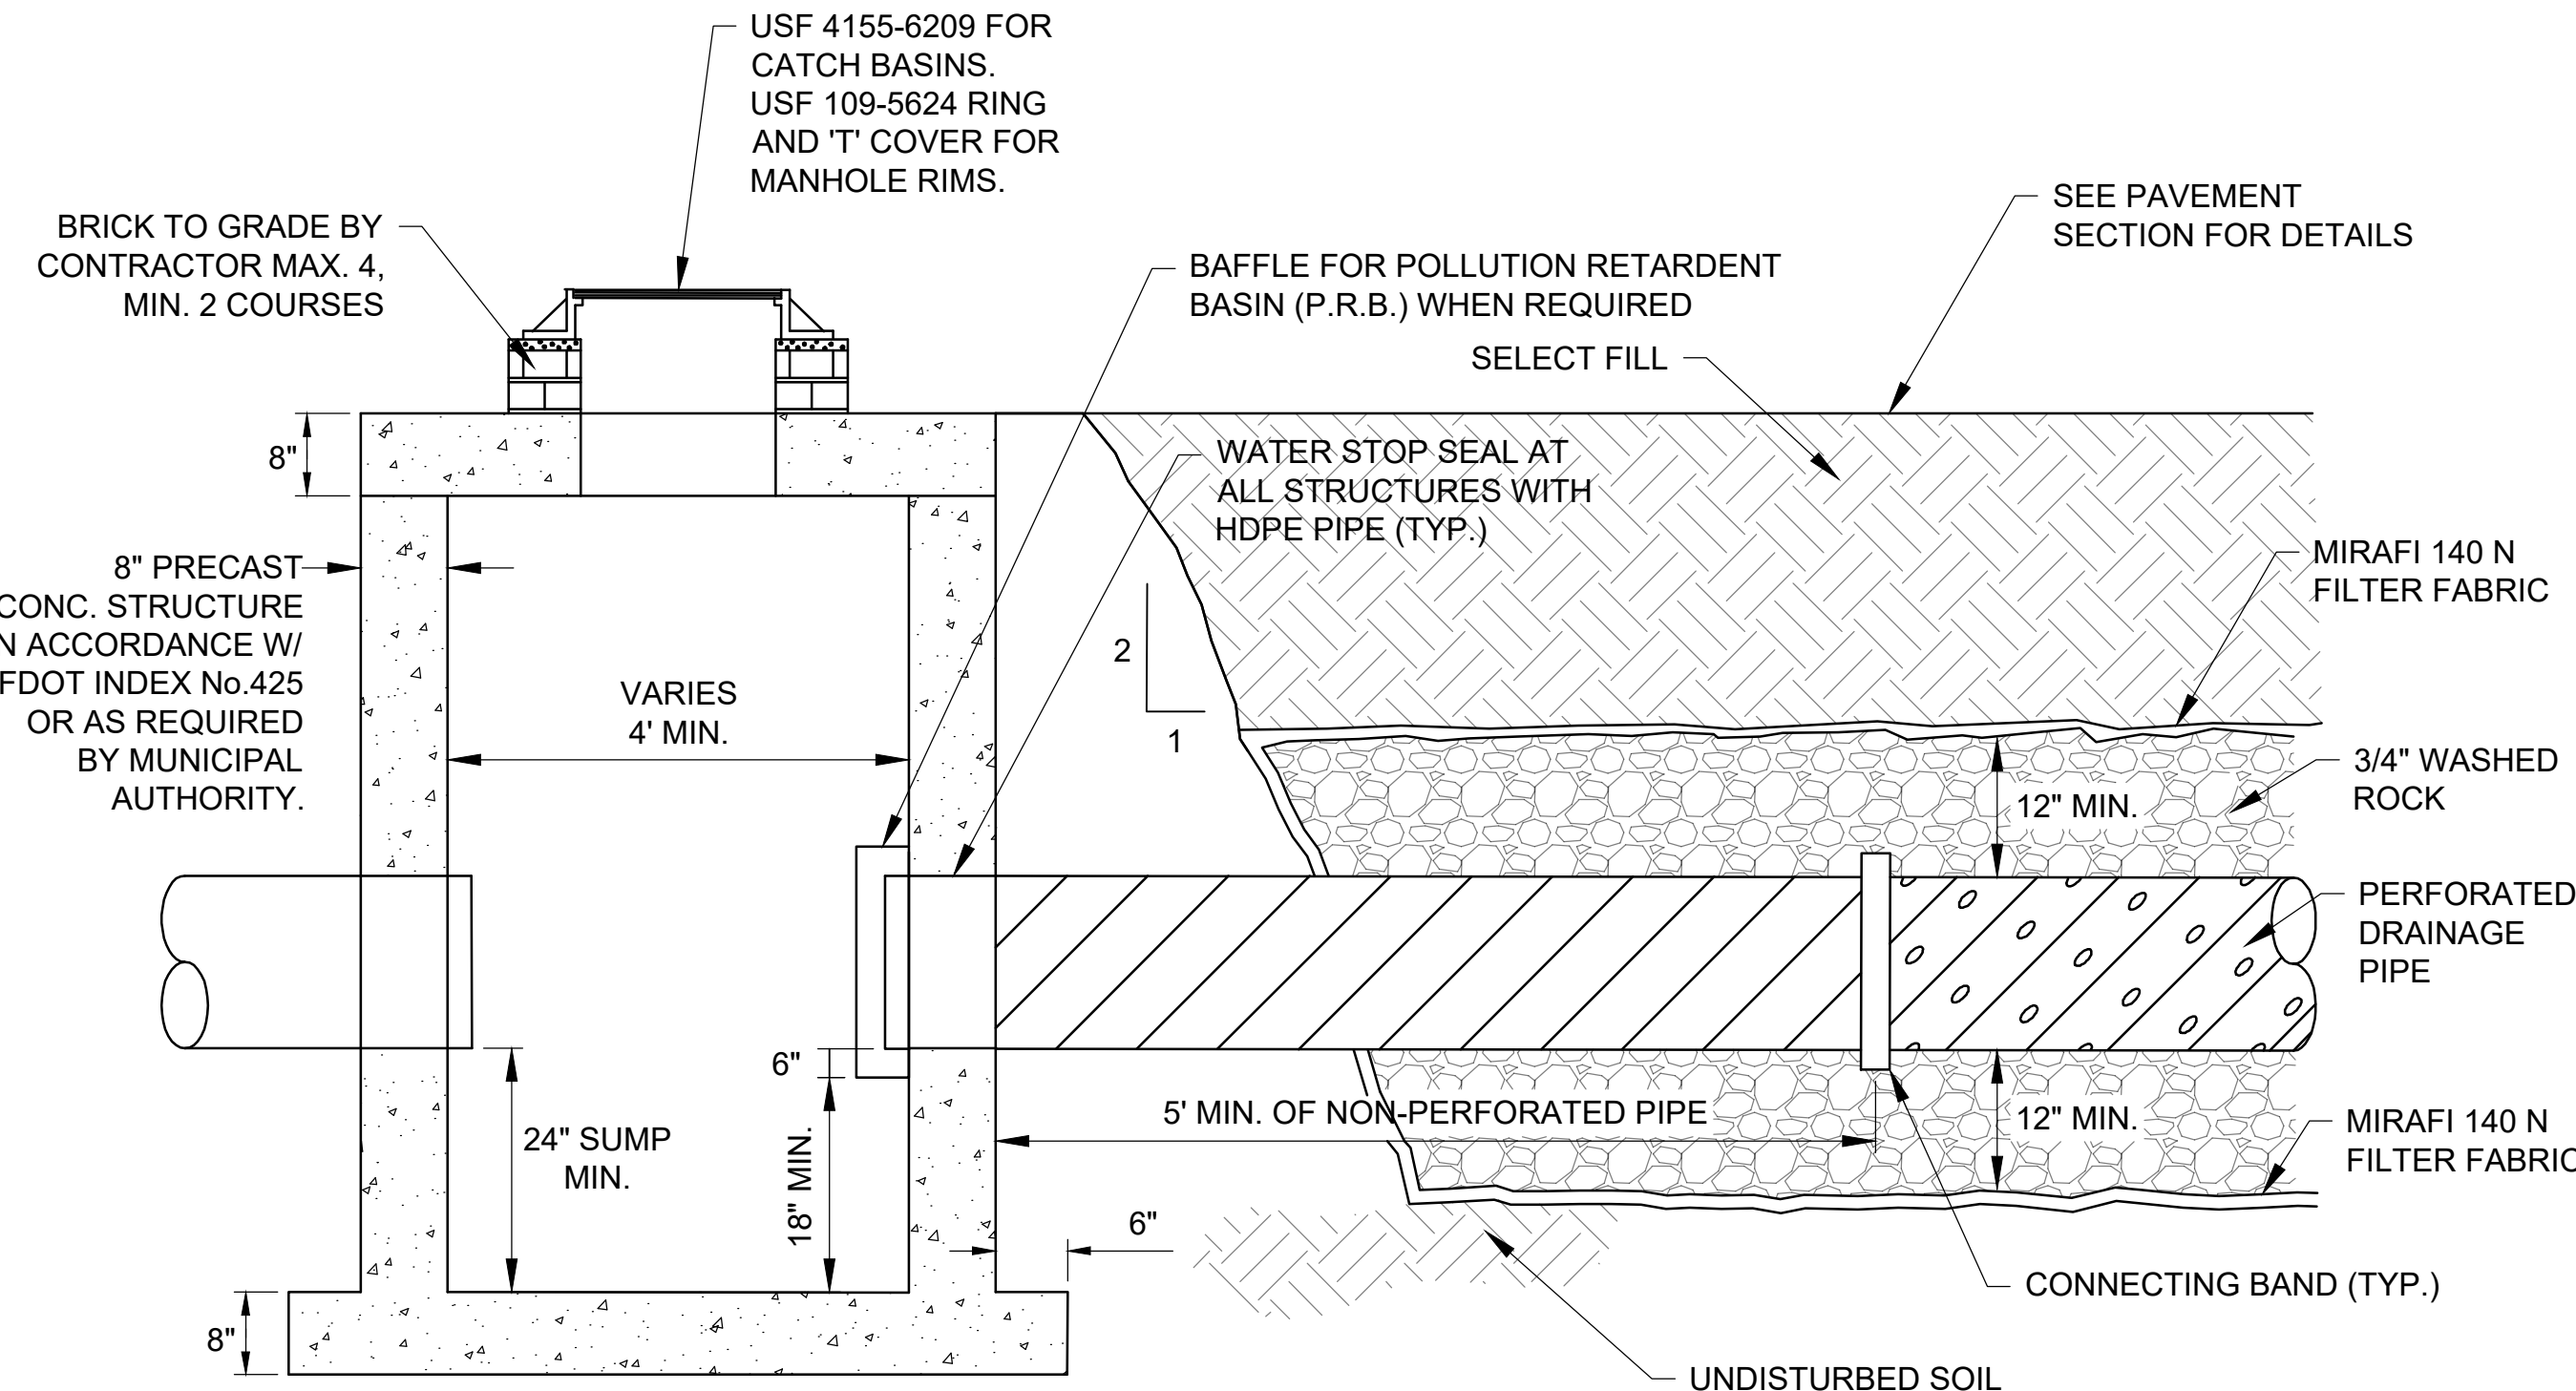

13

CATCH BASIN W/ P.R.B. AND EXFILTRATION TRENCH

SCALE: NOT TO SCALE

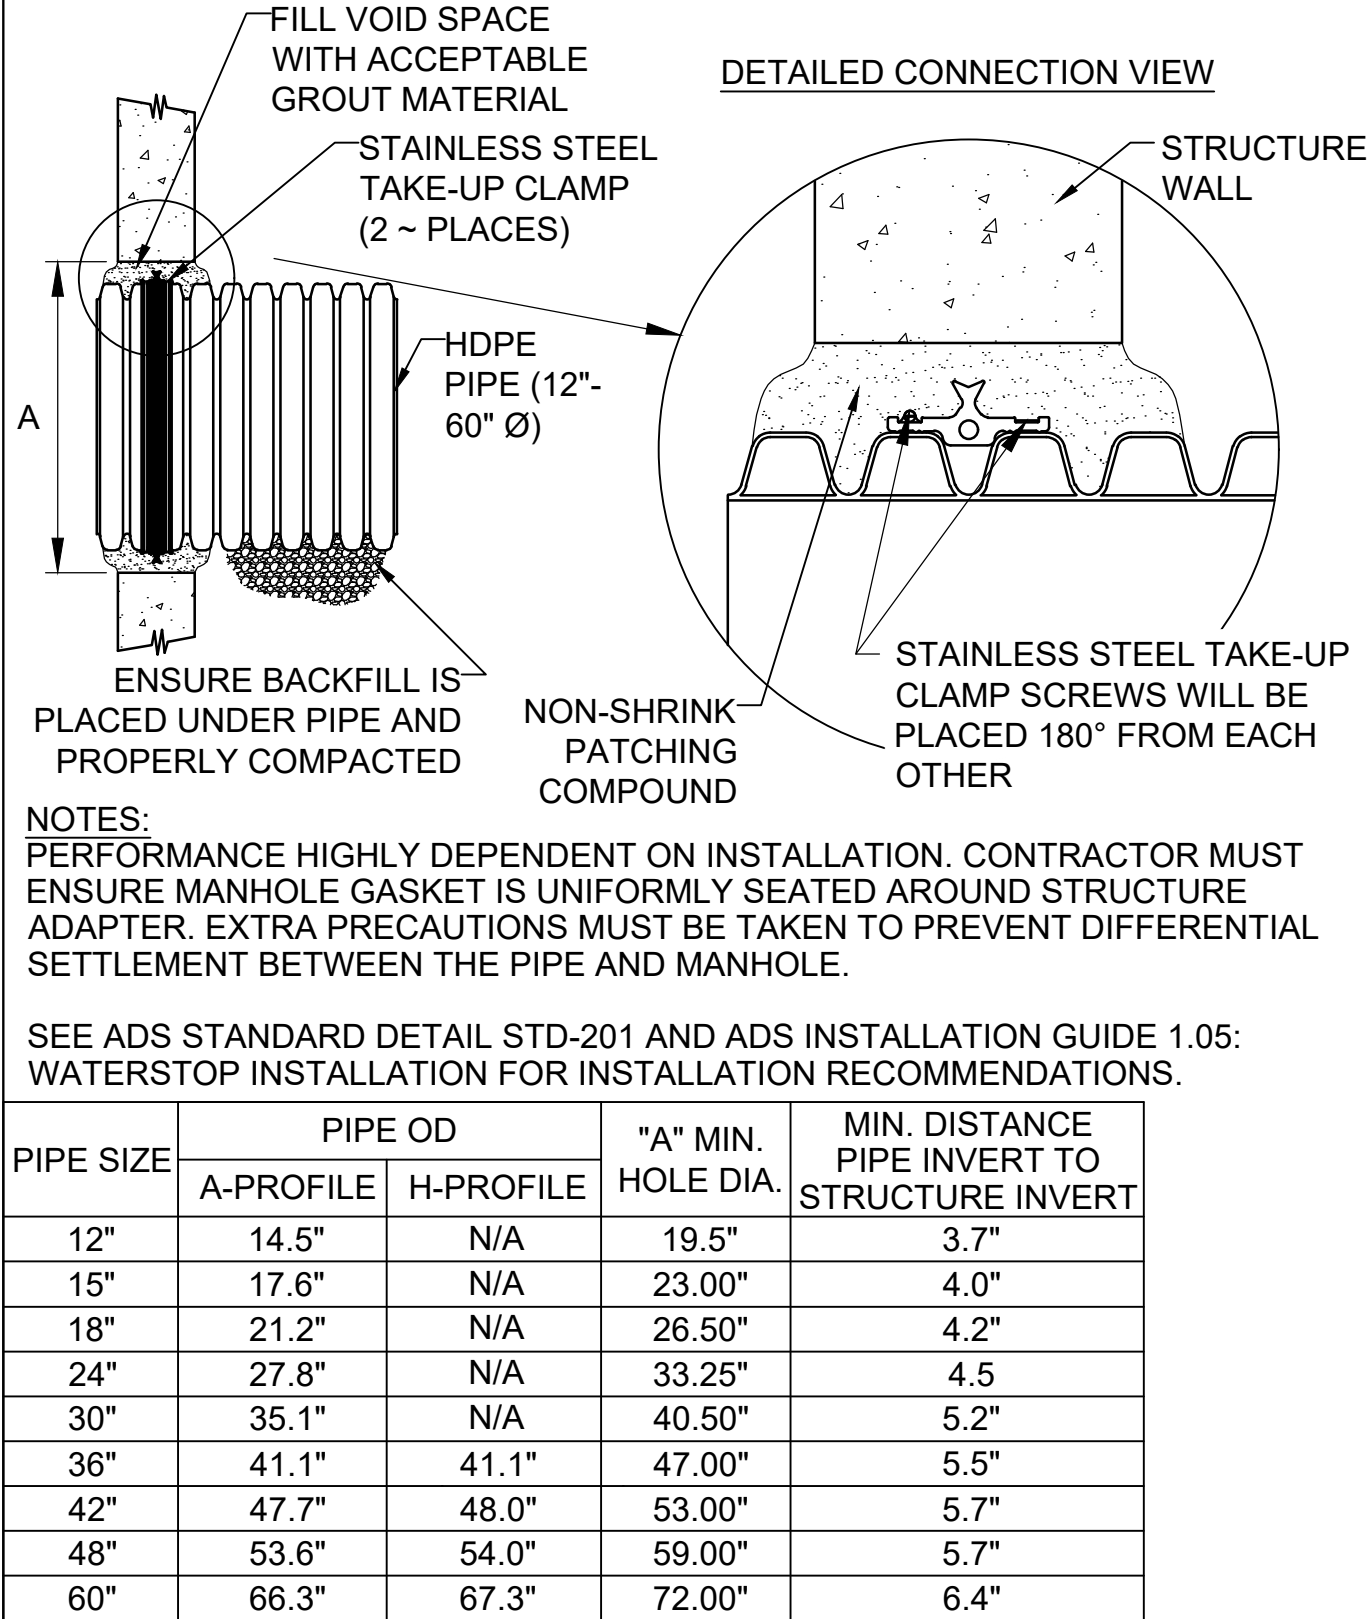

15

GROUTED MANHOLE
CONNECTION (HDPE PIPE) DETAIL

SCALE: NOT TO SCALE

PIPE SIZE	PIPE OD		"A" MIN. HOLE DIA.	MIN. DISTANCE PIPE INVERT TO STRUCTURE INVERT
	A-PROFILE	H-PROFILE		
12"	14.5"	N/A	19.5"	3.7"
15"	17.6"	N/A	23.00"	4.0"
18"	21.2"	N/A	26.50"	4.2"
24"	27.8"	N/A	33.25"	4.5
30"	35.1"	N/A	40.50"	5.2"
36"	41.1"	41.1"	47.00"	5.5"
42"	47.7"	48.0"	53.00"	5.7"
48"	53.6"	54.0"	59.00"	5.7"
60"	66.3"	67.3"	72.00"	6.4"



Corporate Office
301 East Atlantic Boulevard
Pompano Beach, Florida 33060-6643
(954) 788-3400

Miami-Dade County
2160 NW 82 Avenue
Doral, Florida 33122

Palm Beach County
120 N Federal Highway, Suite 208
Lake Worth, Florida 33460

Orange County
2948 E Livingston Street
Orlando, Florida 32803

State of Florida Certificate of
Authorization Number - 7928

BID / CONTRACT NO. :

REVISIONS

NO.	DESCRIPTION	DATE
1	PER DRC COMMENTS	6/8/2017
2	PER DRC COMMENTS	8/24/17
3	PER BCEPGMD COMMENTS	4/2/18
4	PER BCEPGMD COMMENTS	6/15/18

LEDER
HILLSBORO
STORAGE

SCALE: AS NOTED

DATE ISSUED: JANUARY 31, 2018

DRAWN BY: MG

DESIGNED BY: MG


CHECKED BY: SW

SHEET TITLE
PAVING, GRADING
AND DRAINAGE
DETAILS

SHEET NUMBER
CP-503


SHEET 14 of 27

PROJECT NO. 09675.00

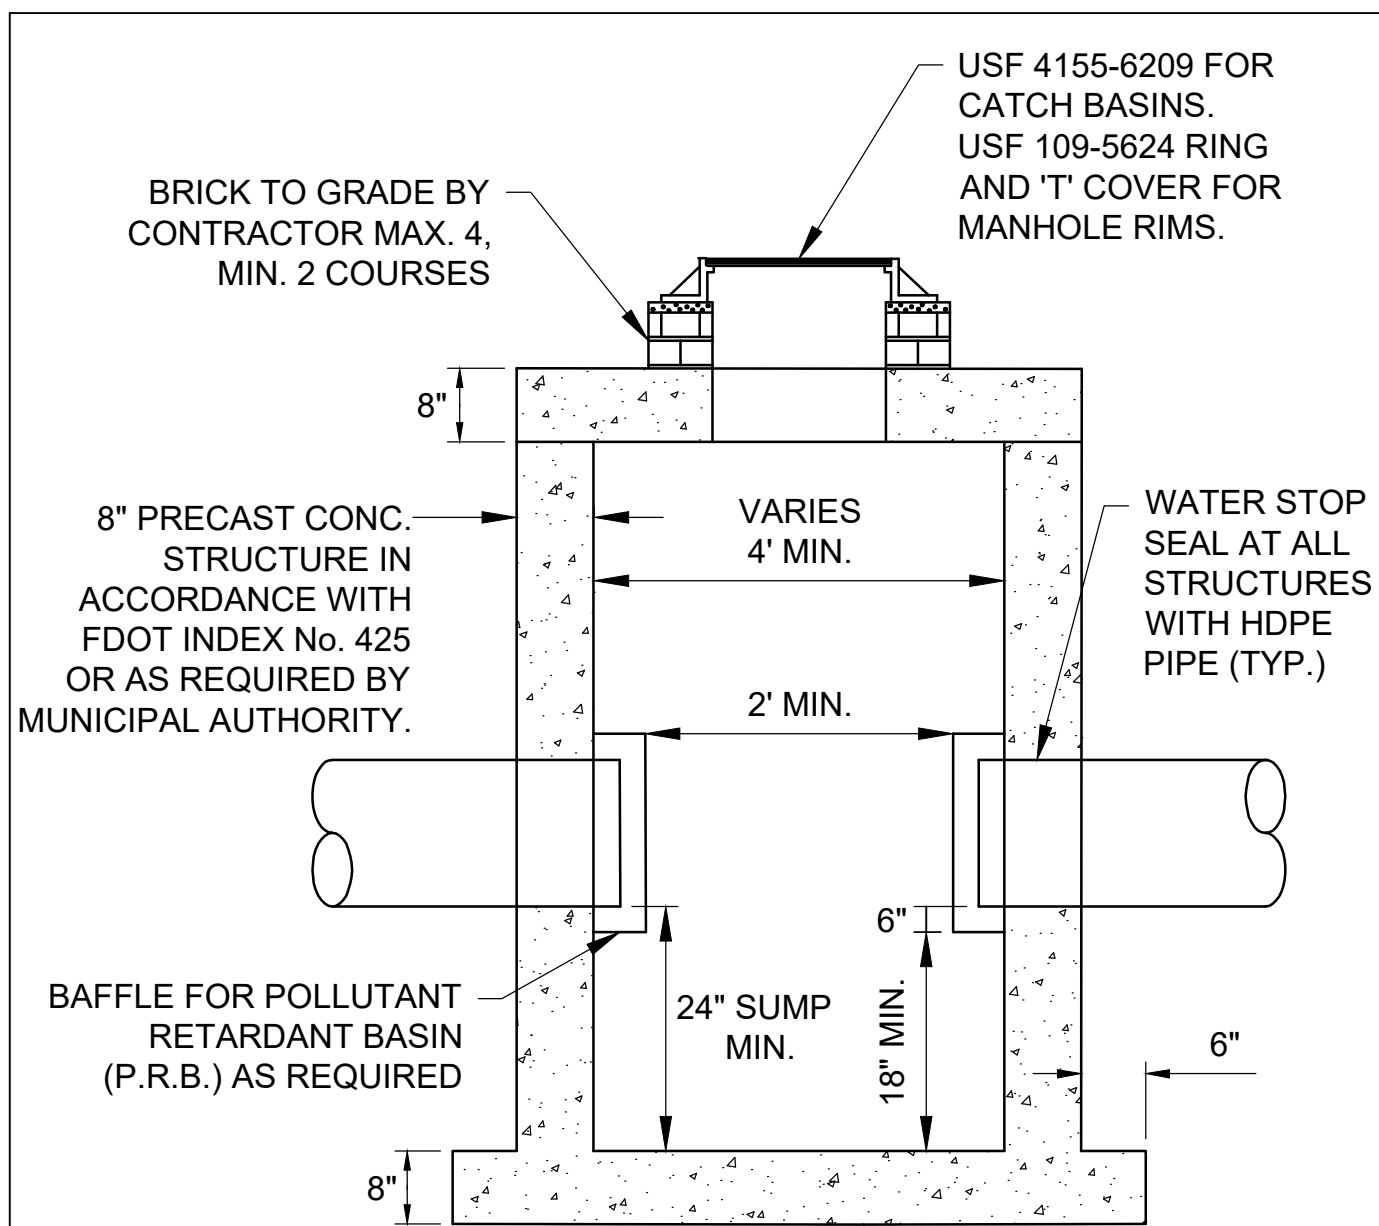


9 CATCH BASIN / DRAINAGE
MANHOLE DETAIL

SCALE: NOT TO SCALE

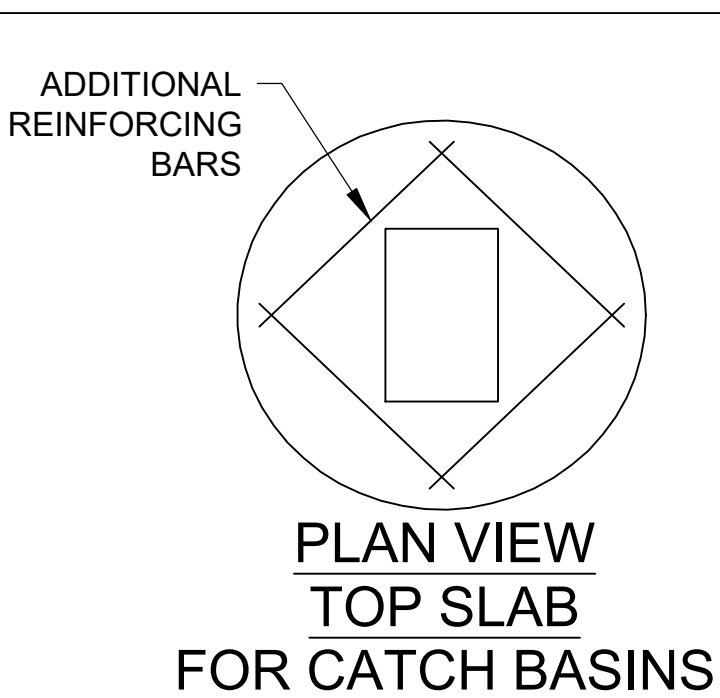


10 CATCH BASIN / MANHOLE
FRAME DETAIL

SCALE: NOT TO SCALE

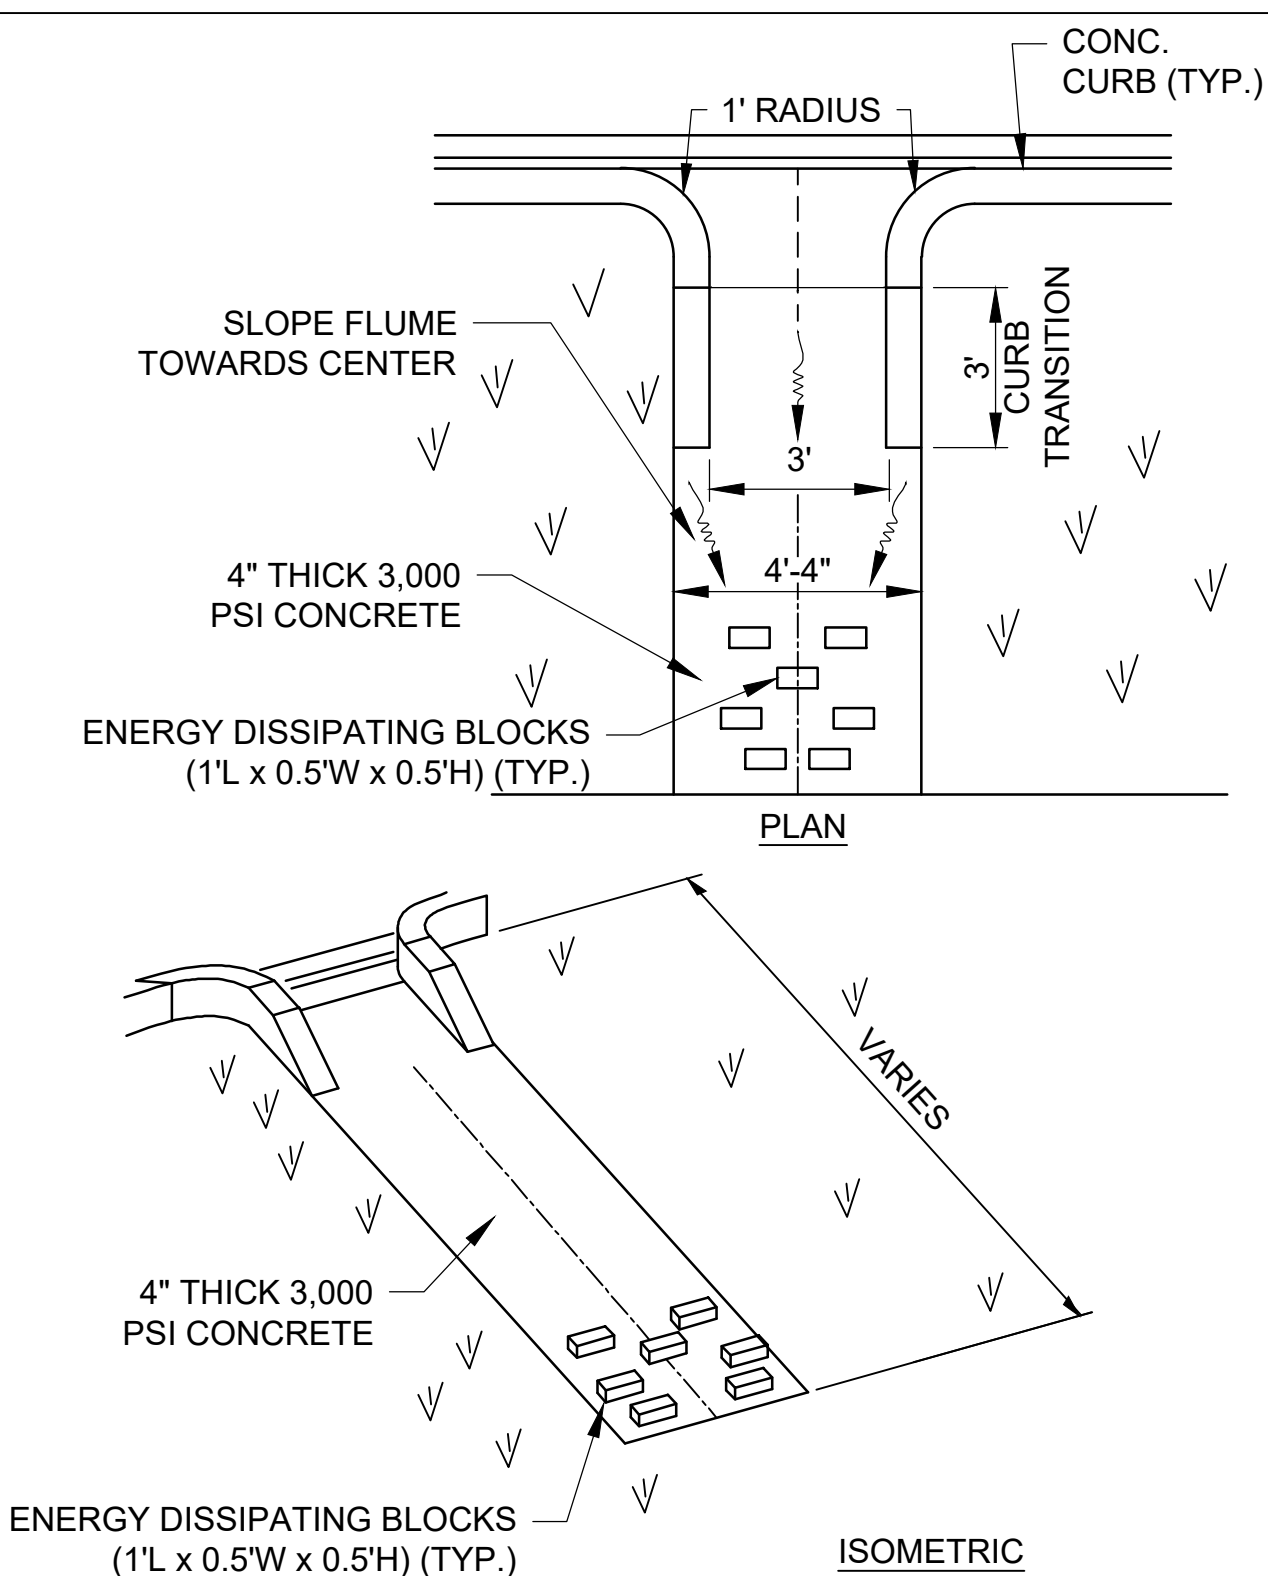


14 CONCRETE FLUME DETAIL

SCALE: NOT TO SCALE

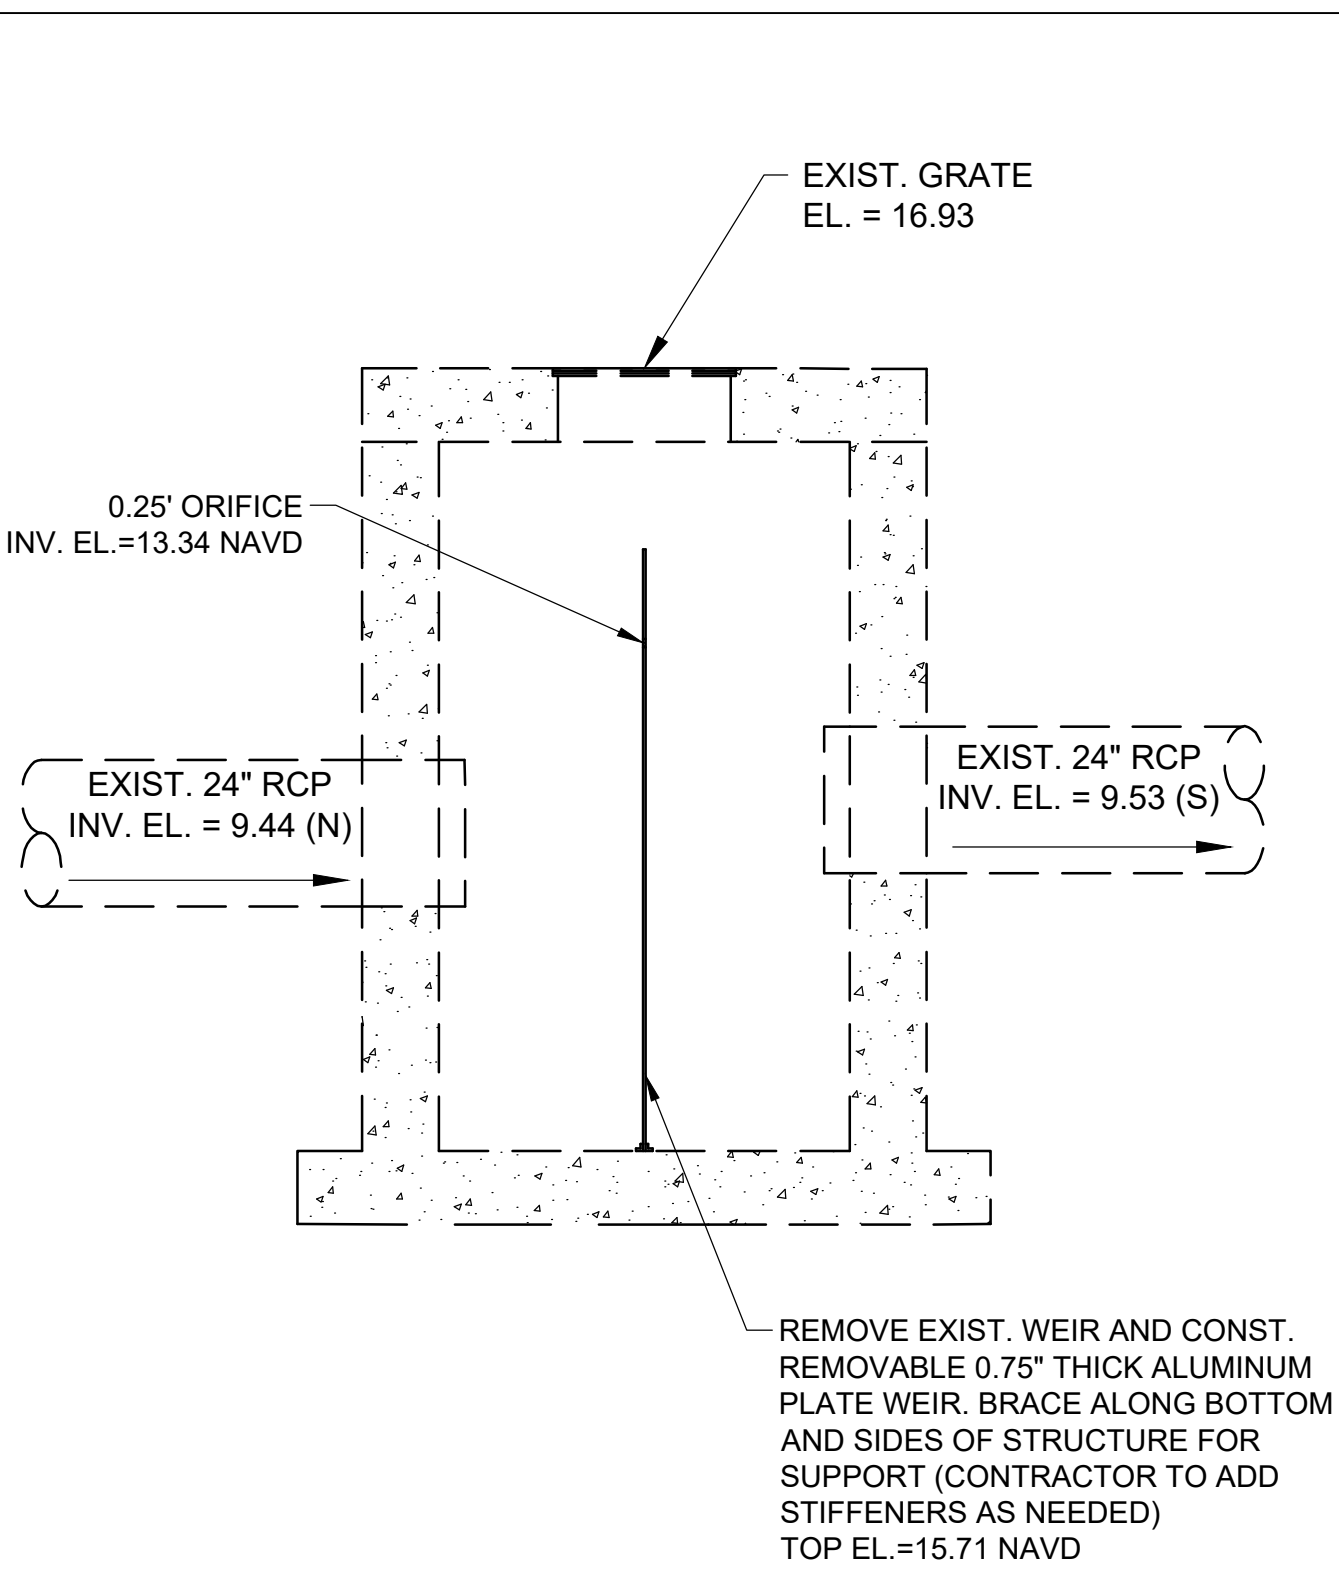


16 EXISTING CONTROL STRUCTURE
MODIFICATION DETAIL

SCALE: NOT TO SCALE

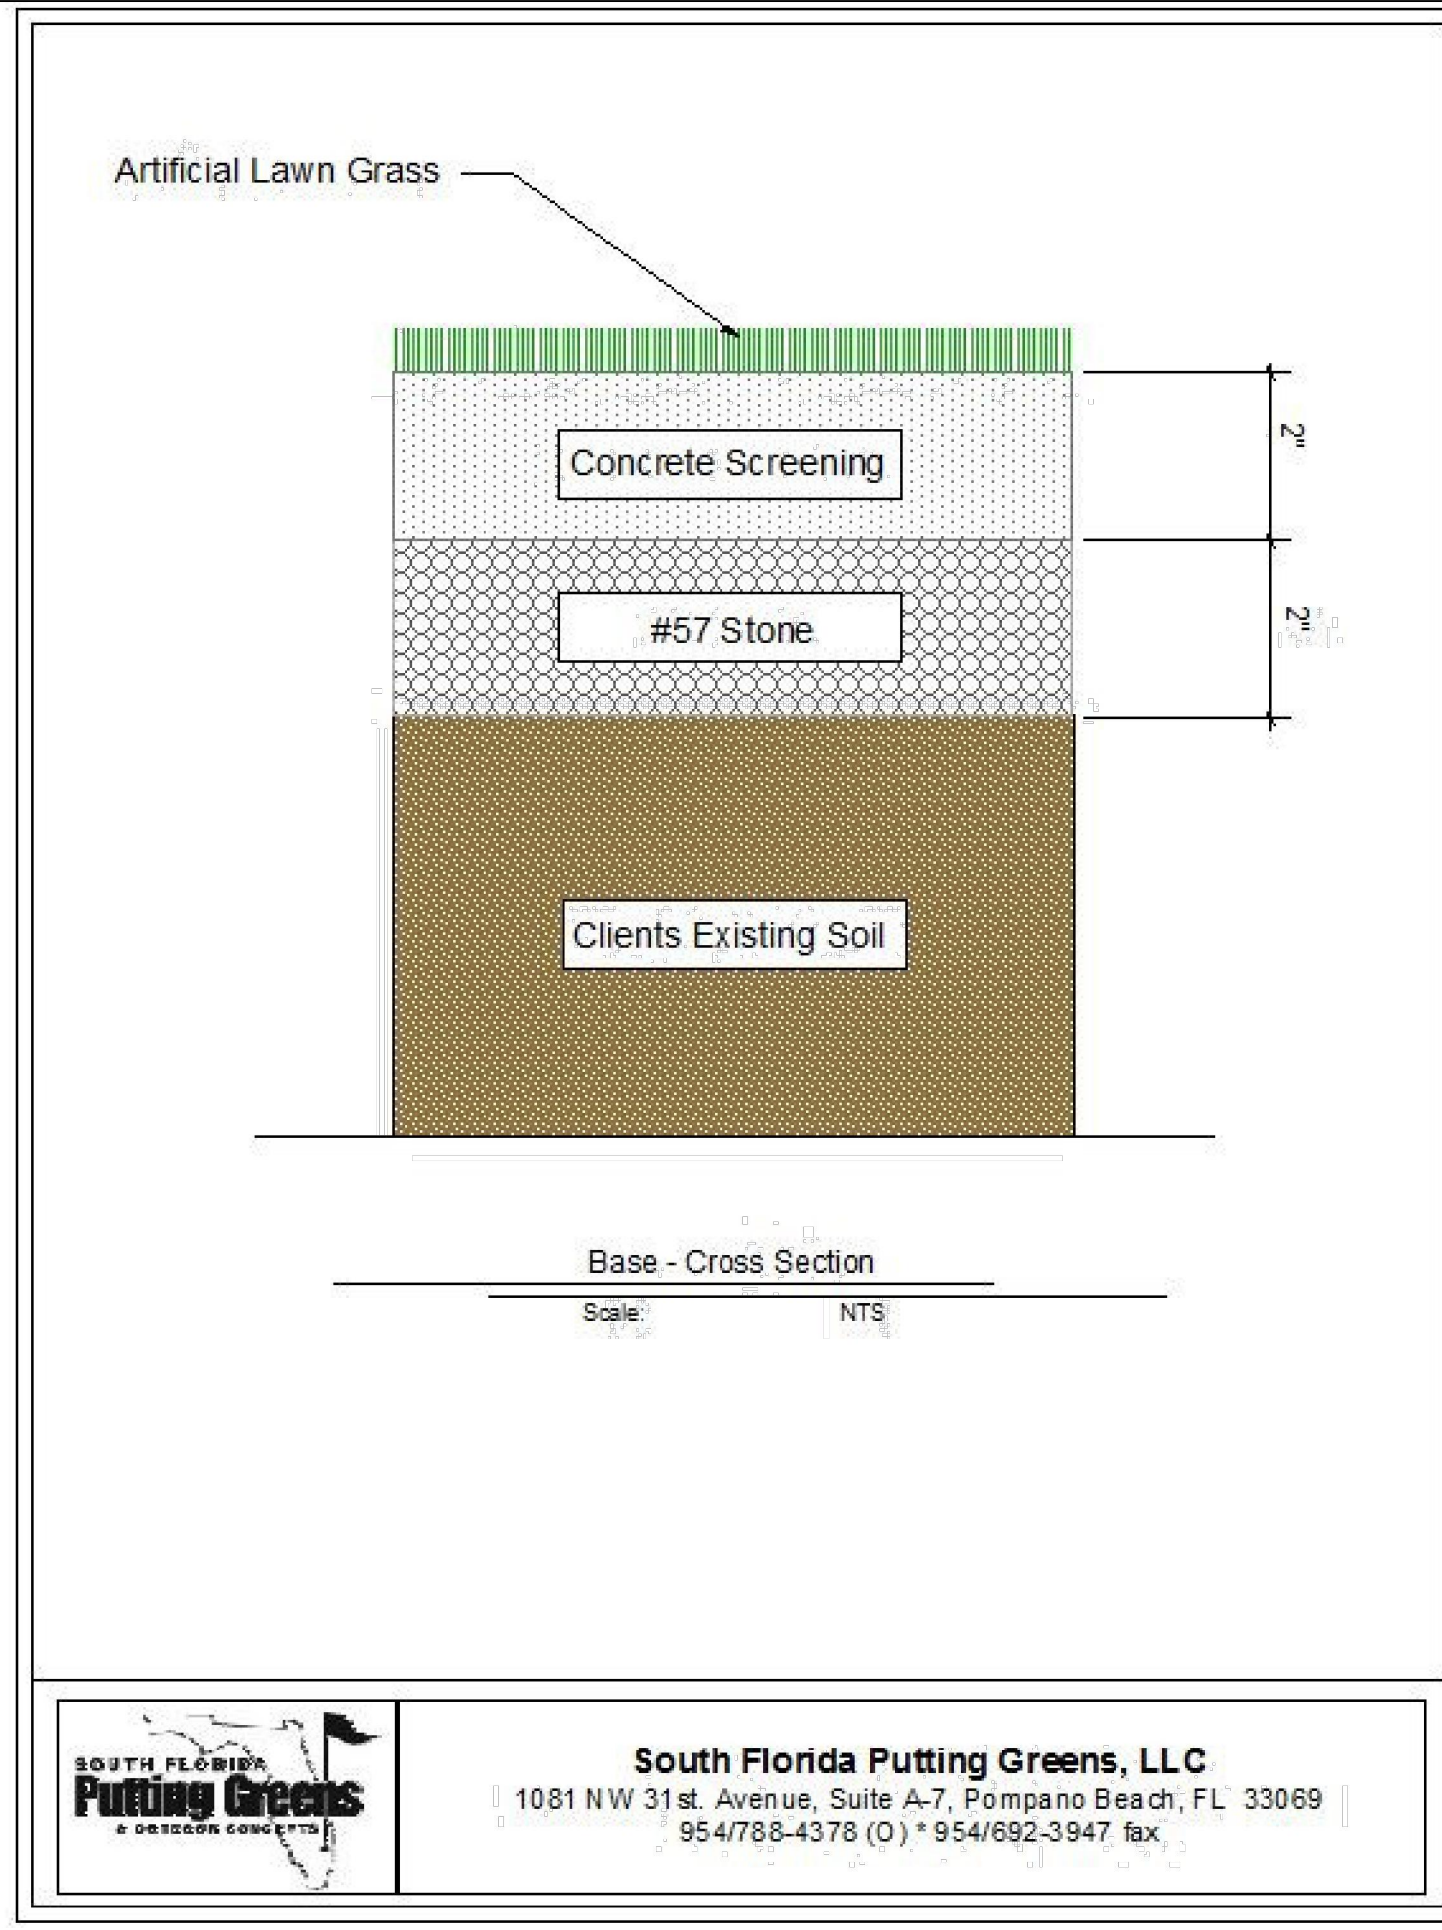

South Florida Putting Greens, LLC
1081 NW 31st Avenue, Suite A-7, Pompano Beach, FL 33069
954/788-4378 (O) * 954/692-3947 fax

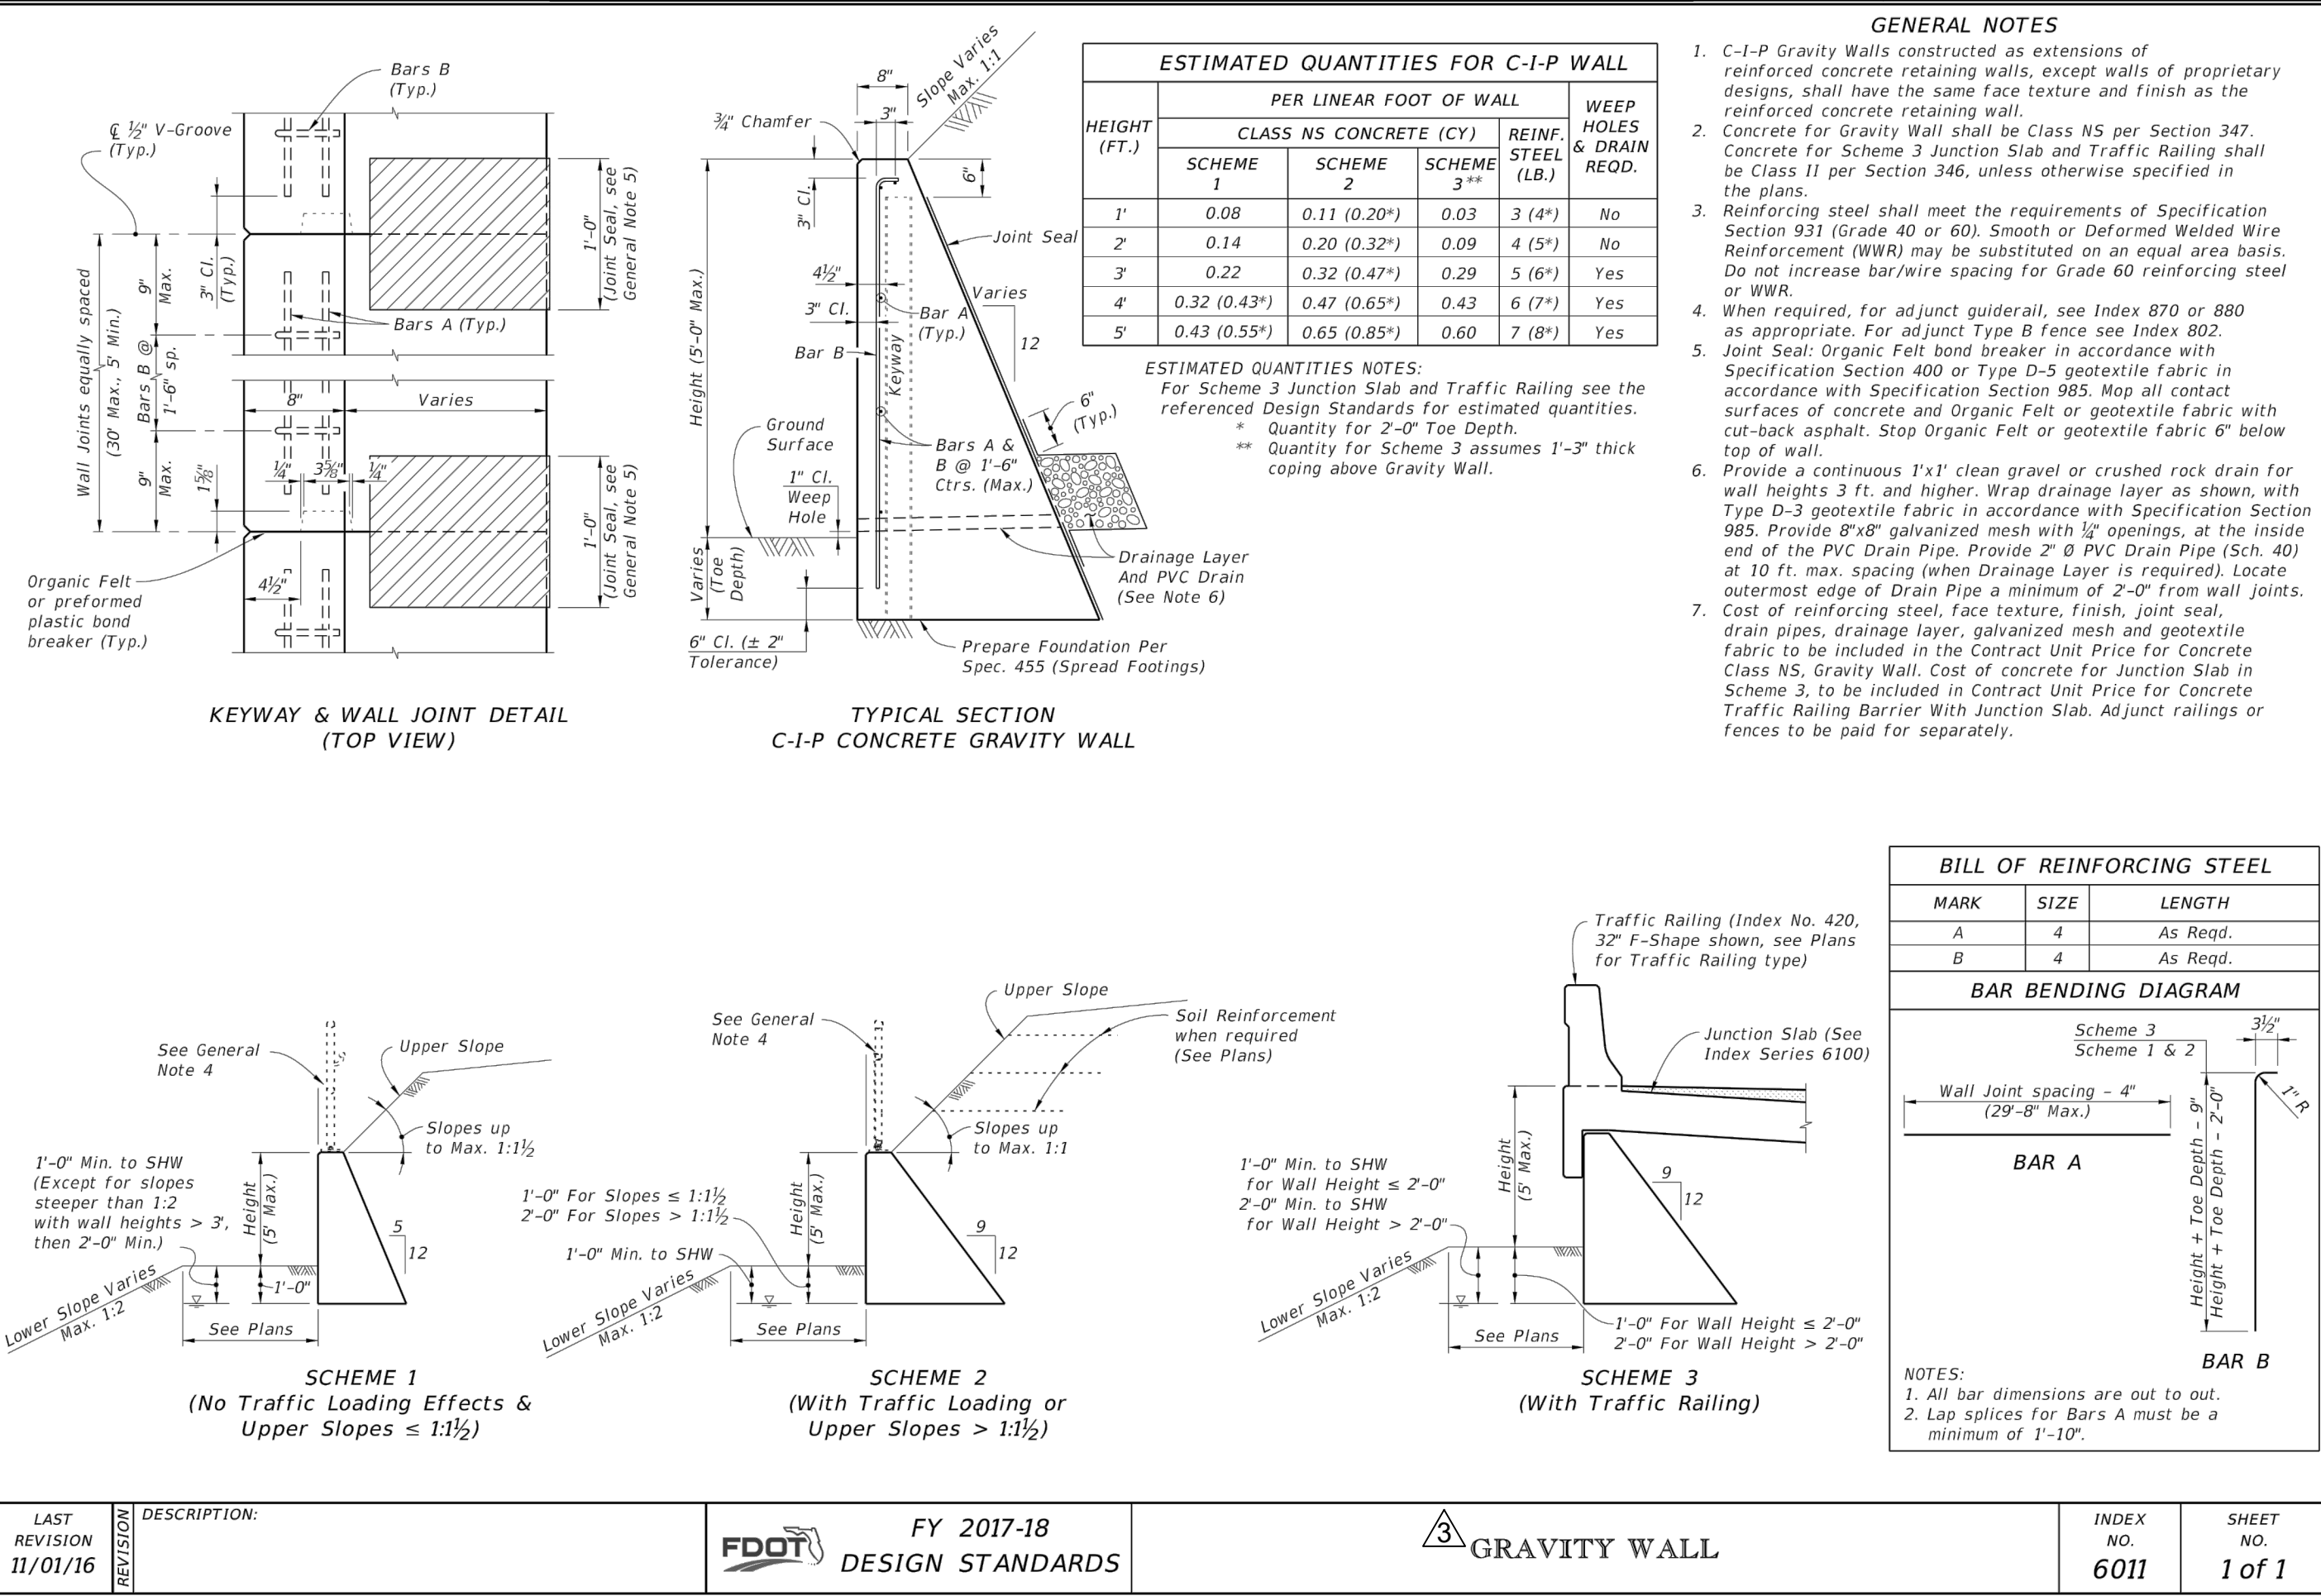

LAST REVISION
11/01/16

DESCRIPTION:

FDOT FY 2017-18
DESIGN STANDARDS

GRAVITY WALL

INDEX NO. 6011
SHEET NO. 1 of 1



Corporate Office
301 East Atlantic Boulevard
Pompano Beach, Florida 33060-6643
(954) 788-3400

Miami-Dade County
2160 NW 82 Avenue
Doral, Florida 33122

Palm Beach County
120 N Federal Highway, Suite 208
Lake Worth, Florida 33460

Orange County
2948 E Livingston Street
Orlando, Florida 32803

State of Florida Certificate of
Authorization Number - 7928

BID / CONTRACT NO. :

REVISIONS

NO.	DESCRIPTION	DATE
1	PER DRC COMMENTS	6/8/2017
2	PER DRC COMMENTS	8/24/17
3	PER CITY COMMENTS	12/28/2017
4	PER FDOT COMMENTS	2/7/18
5	PER BCEPGMD COMMENTS	6/15/18

LEDER
HILLSBORO
STORAGE

SCALE: AS NOTED

DATE ISSUED: JANUARY 31, 2018

DRAWN BY: MG

DESIGNED BY: MG

CHECKED BY: SW

STEPHEN D. WILLIAMS, P.E.
FLORIDA REG. NO. 32090
(FOR THE FIRM)

SHEET TITLE







PAVING, GRADING
AND DRAINAGE
DETAILS


SHEET NUMBER

CP-504


SHEET 15 of 27

PROJECT NO. 09675.00

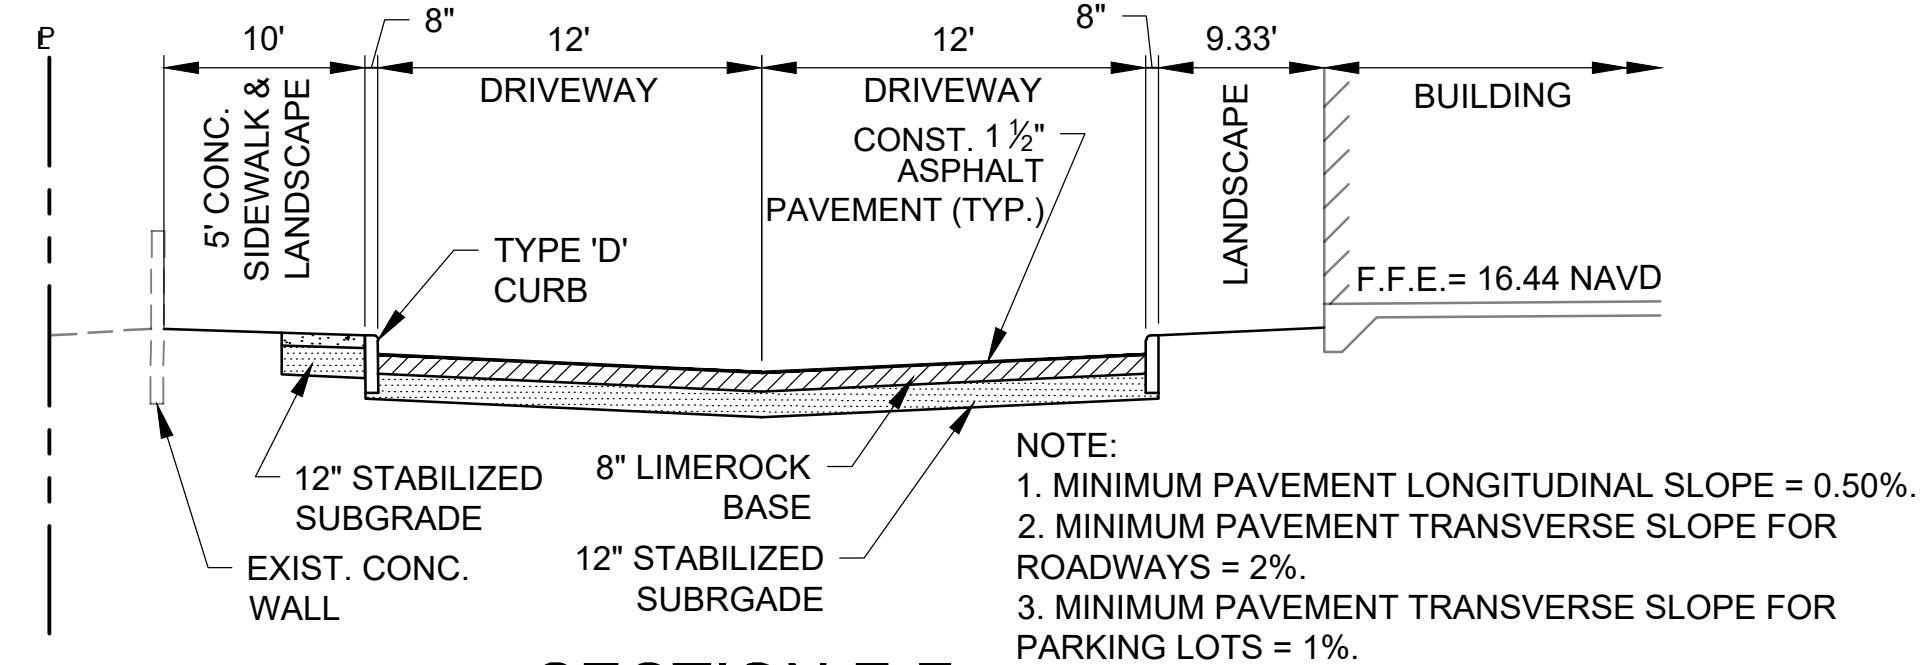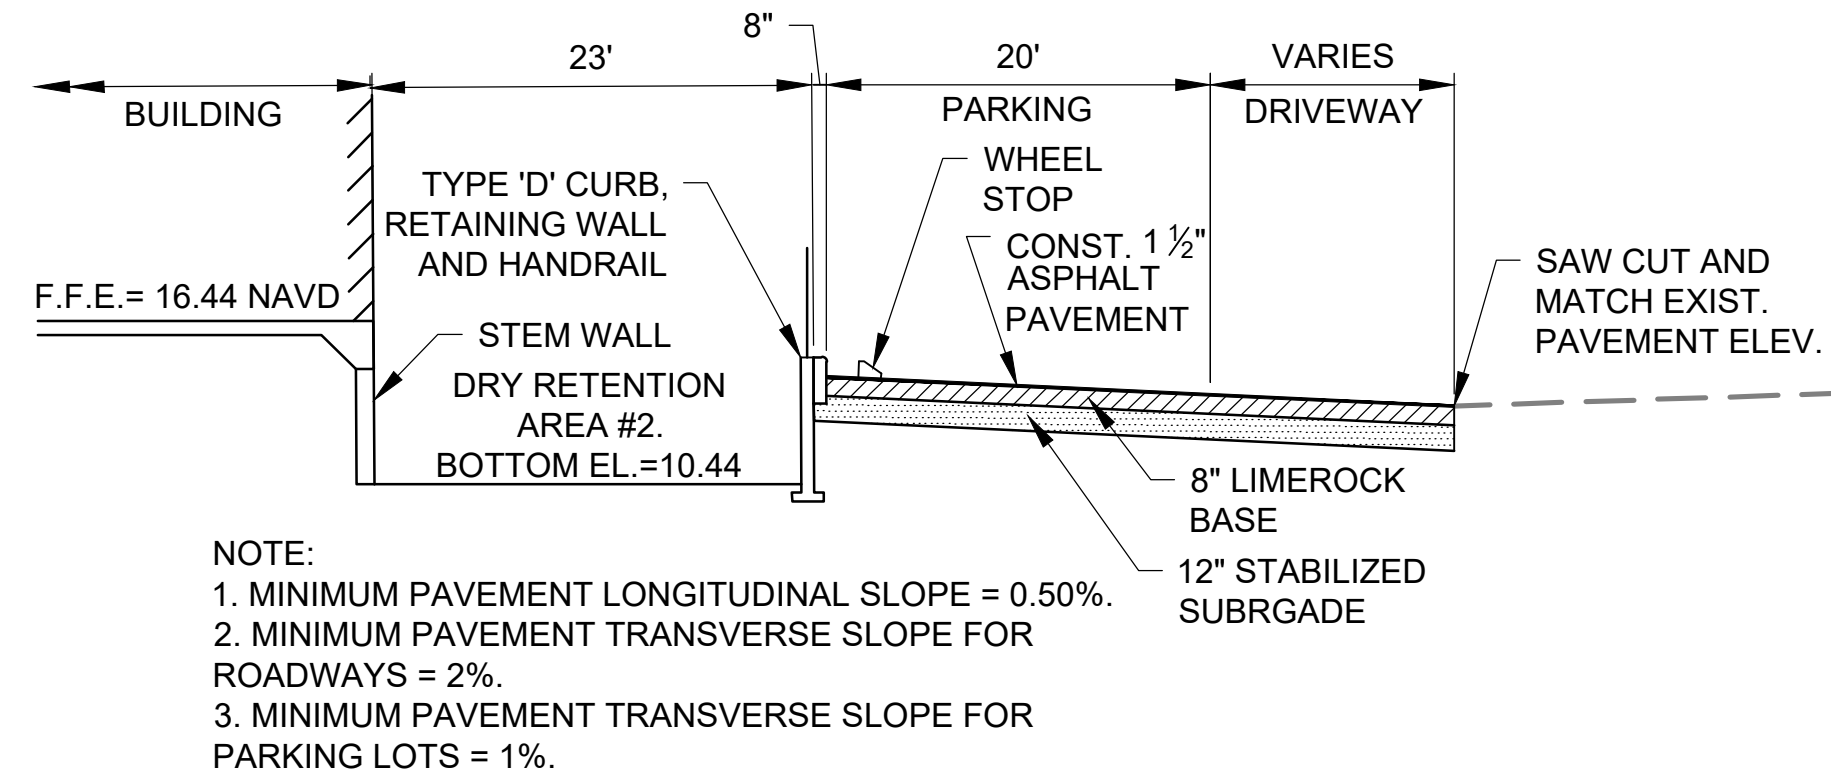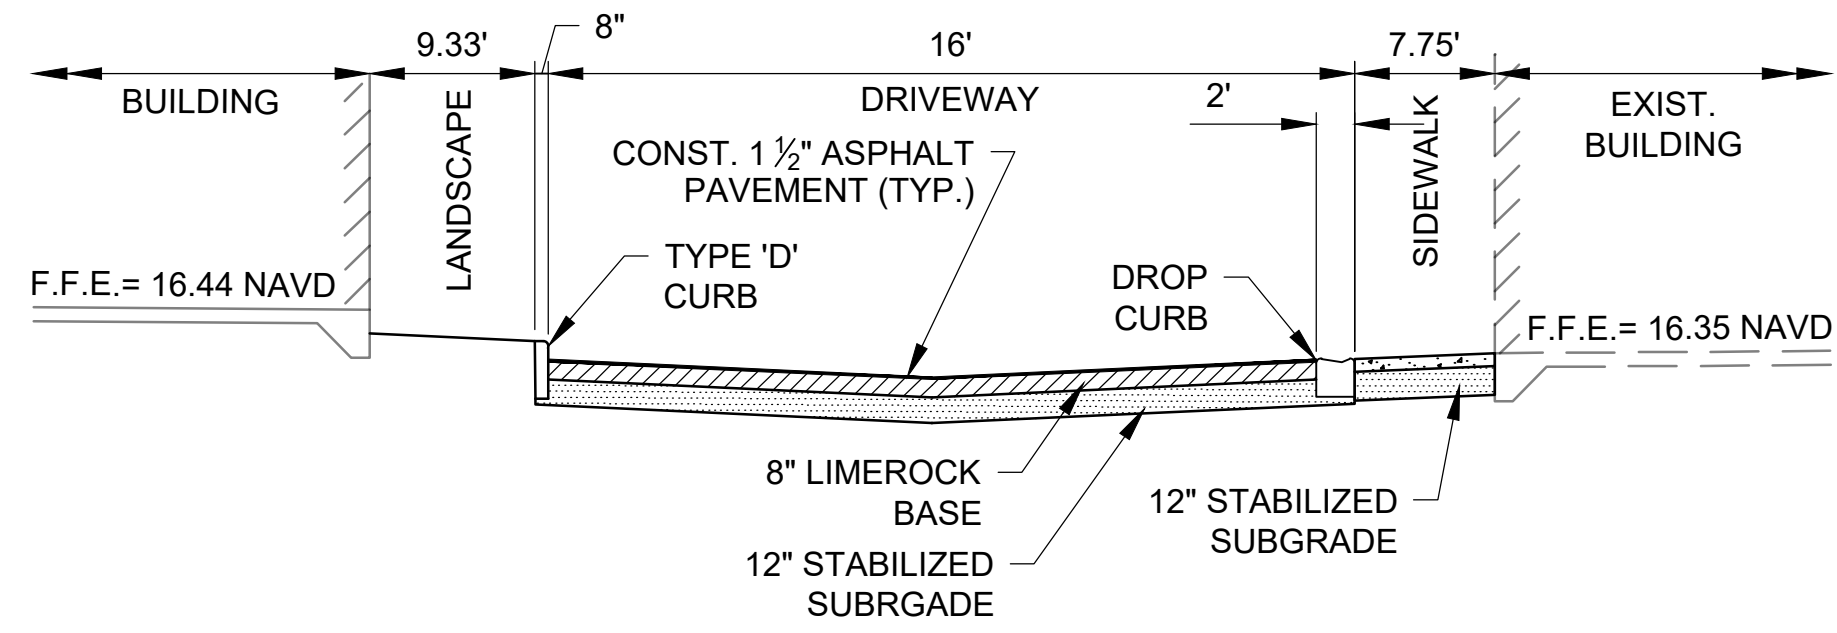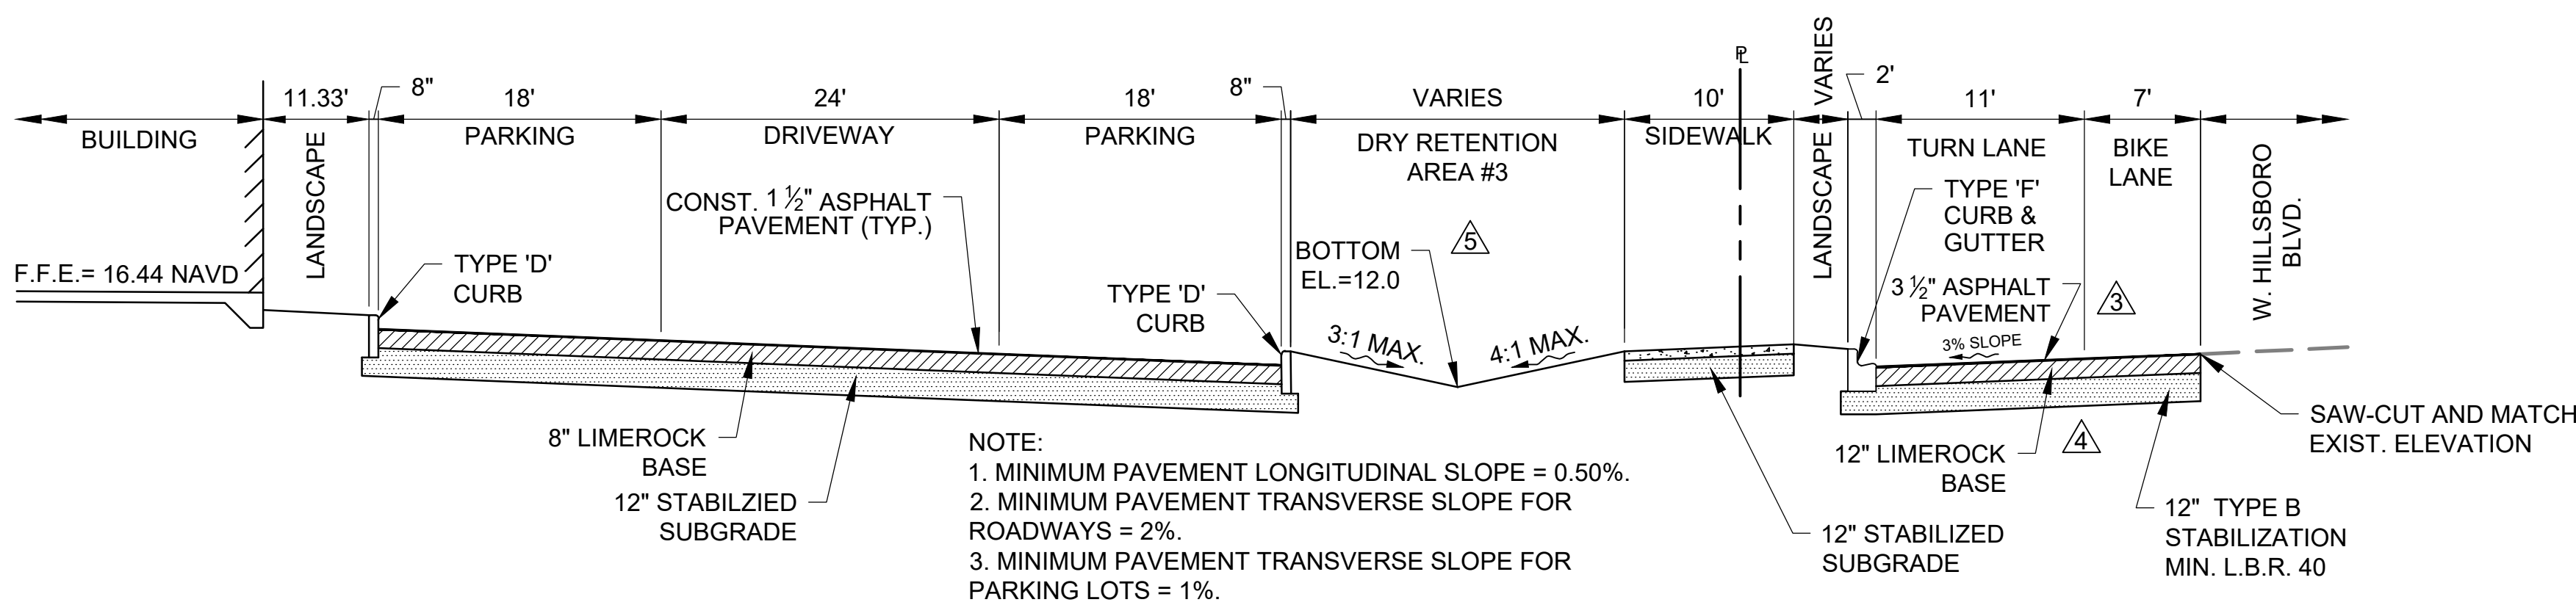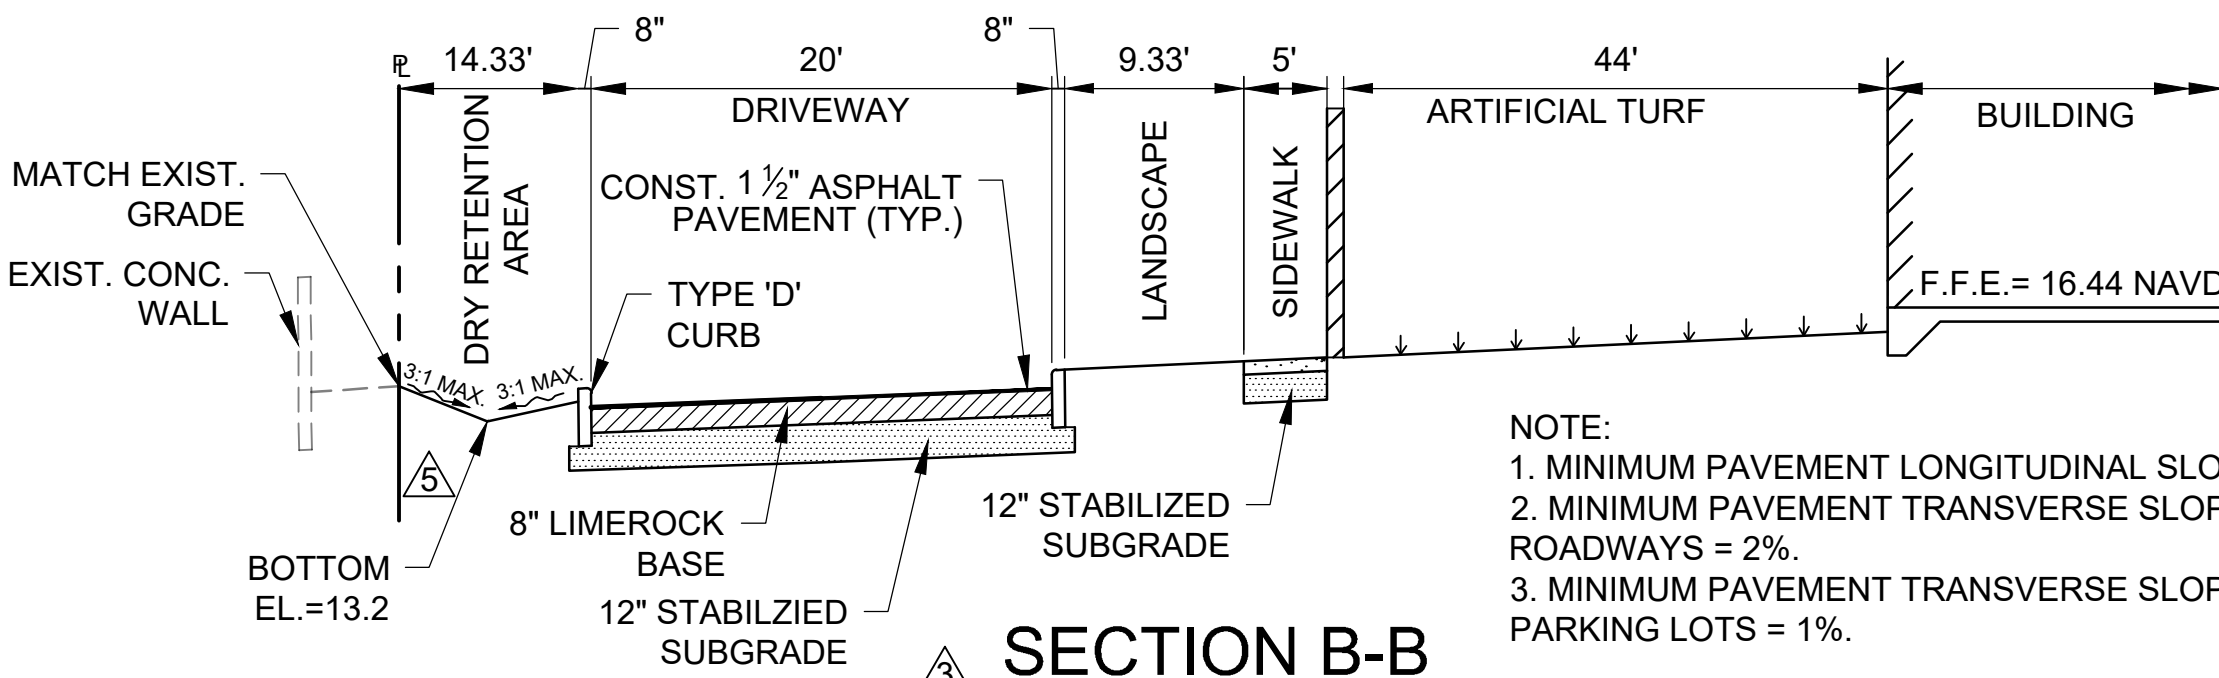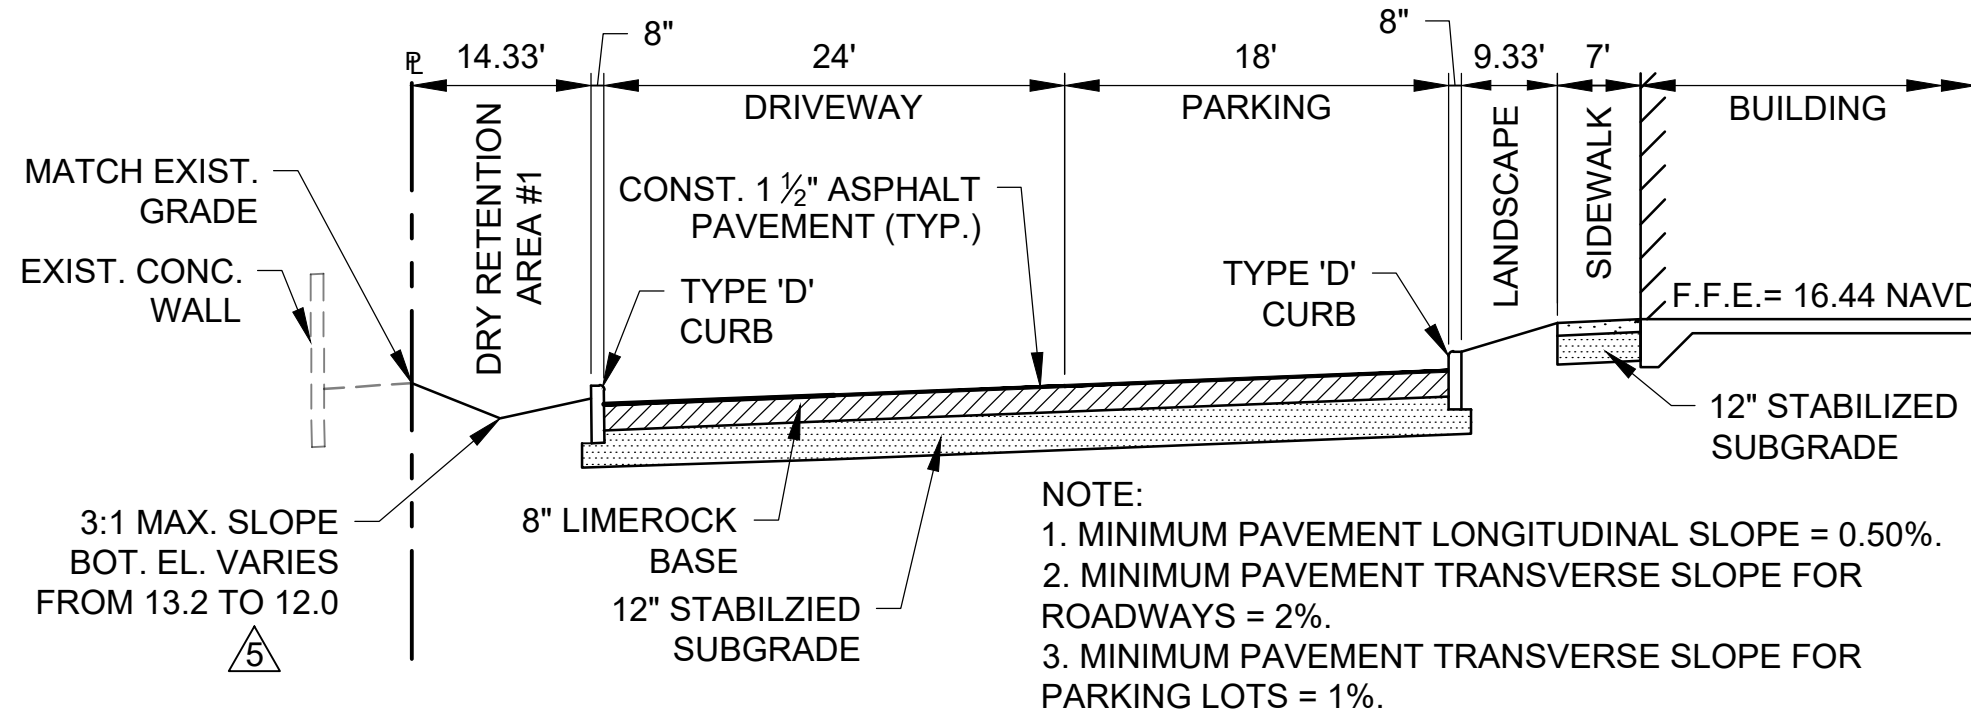

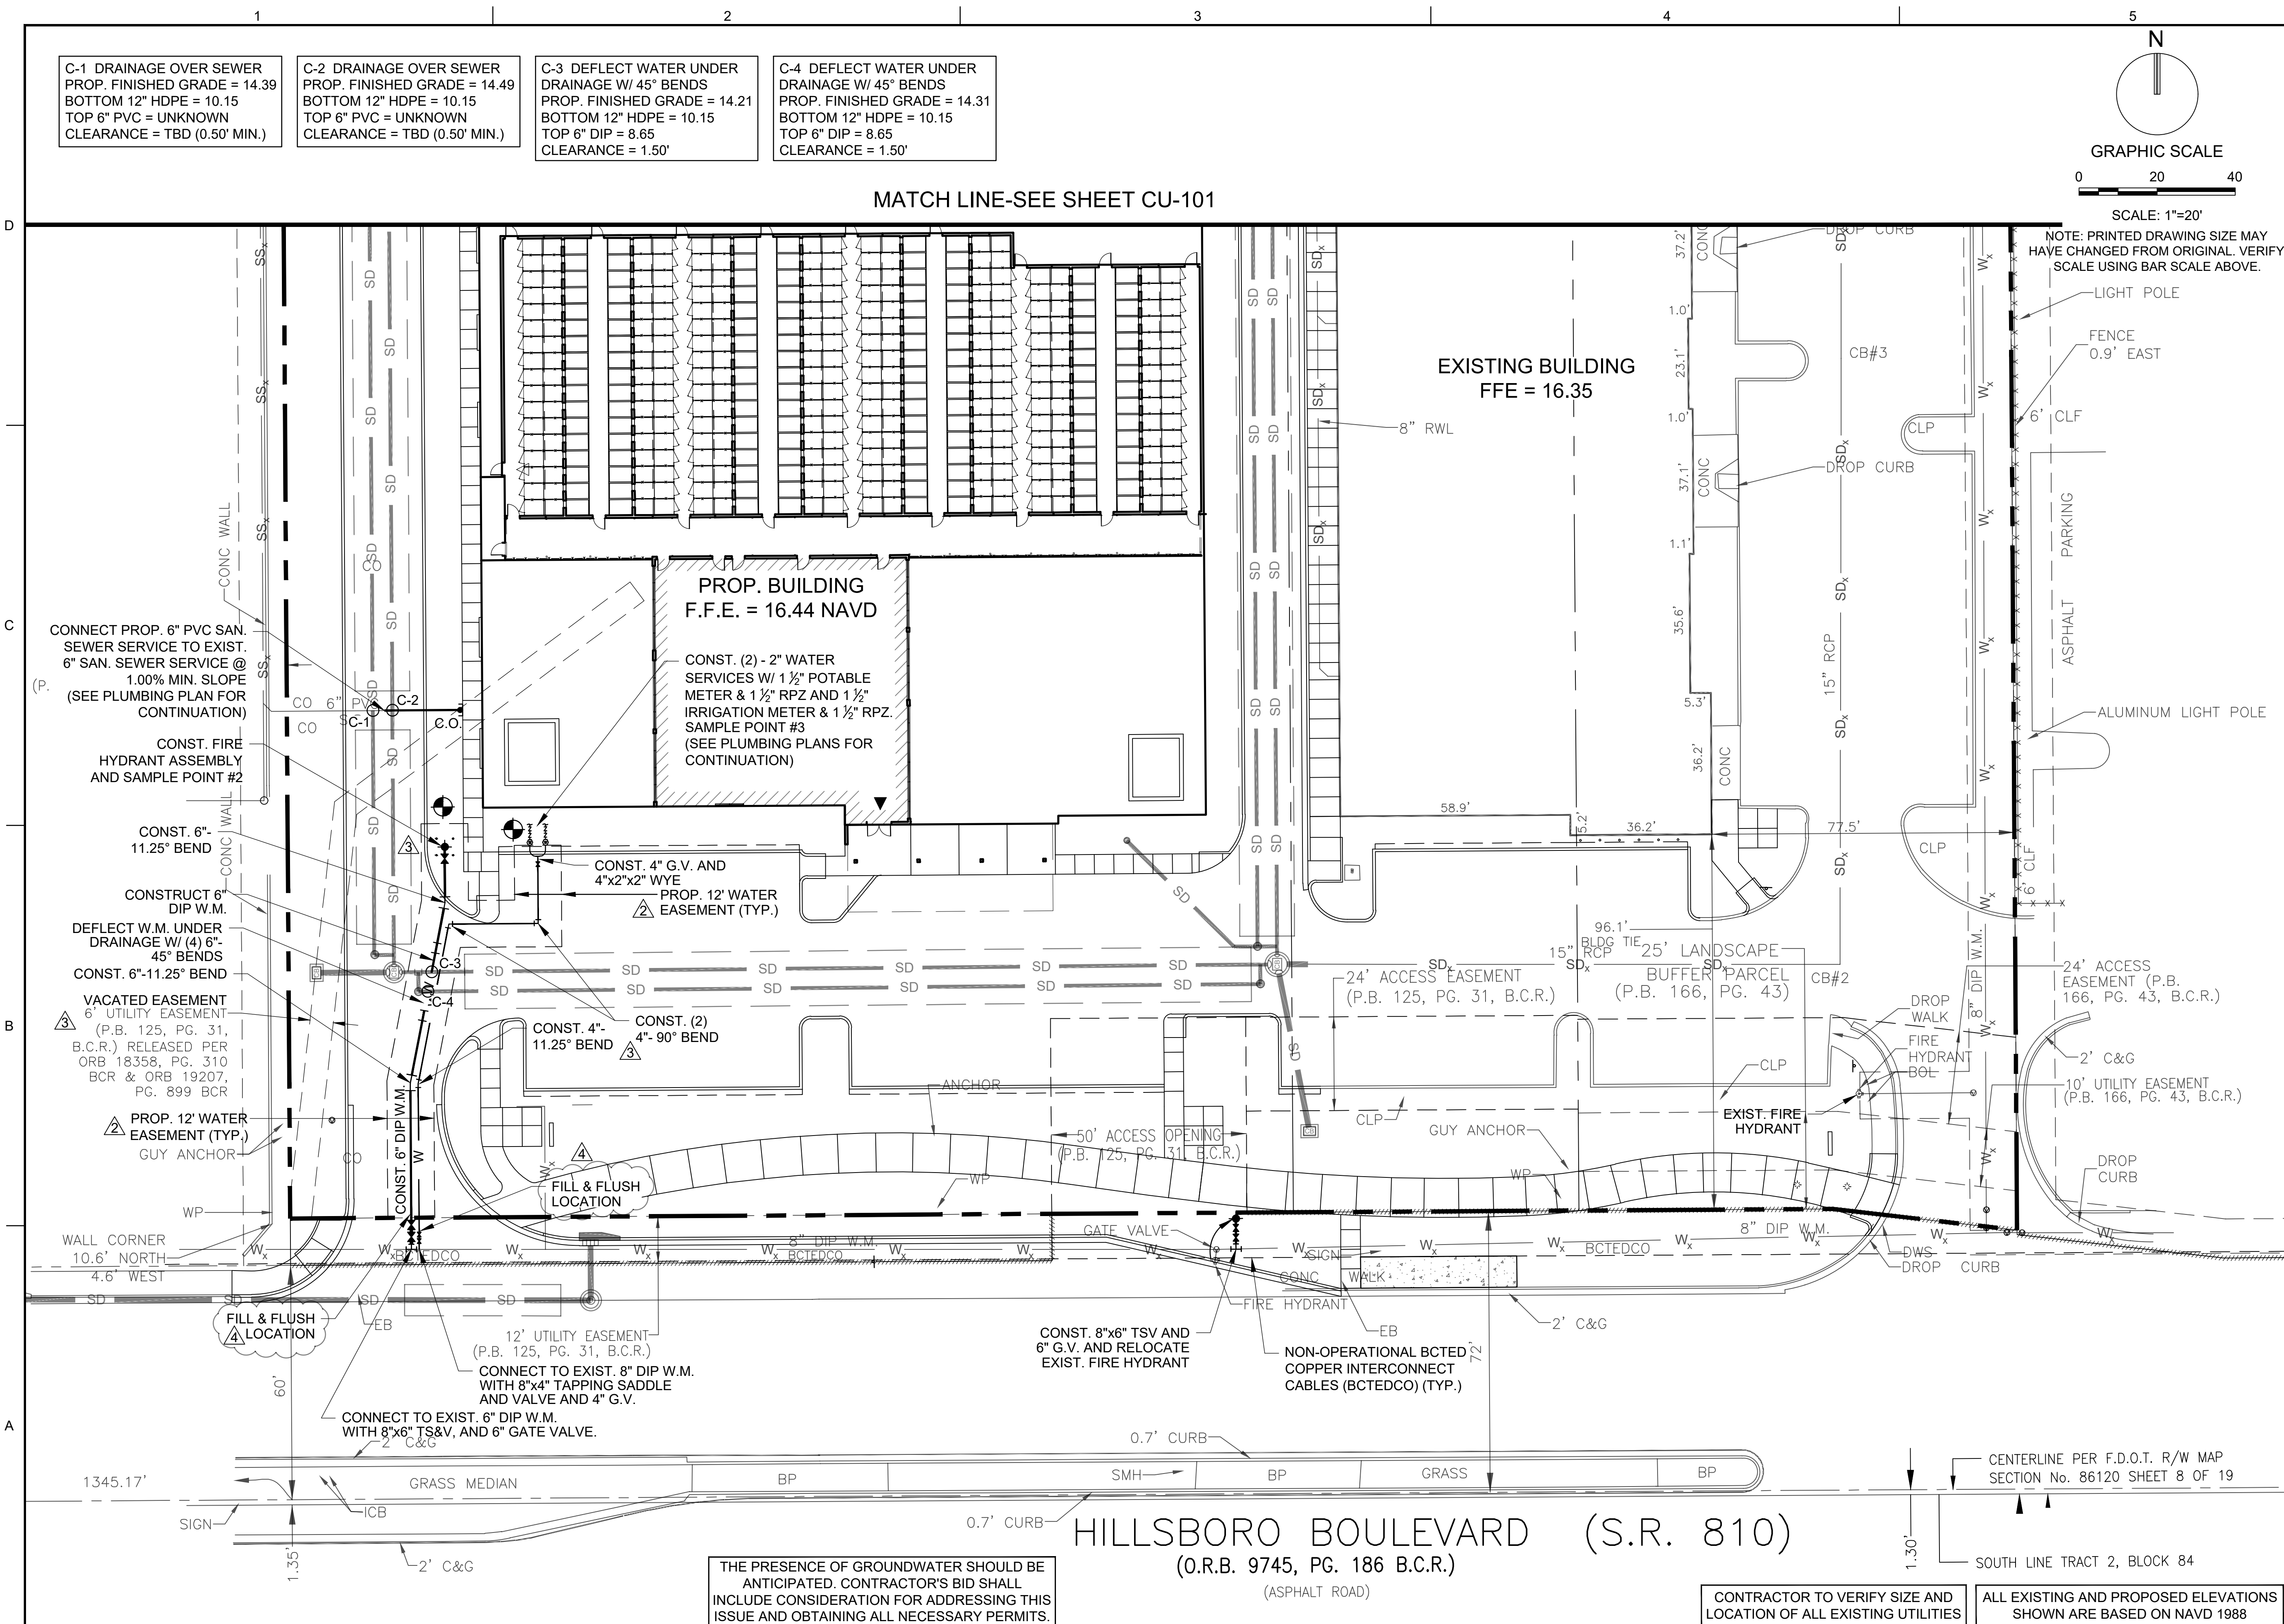

- C-1 DRAINAGE OVER SEWER
PROP. FINISHED GRADE = 14.39
BOTTOM 12" HDPE = 10.15
TOP 6" PVC = UNKNOWN
CLEARANCE = TBD (0.50' MIN.)
- C-2 DRAINAGE OVER SEWER
PROP. FINISHED GRADE = 14.49
BOTTOM 12" HDPE = 10.15
TOP 6" PVC = UNKNOWN
CLEARANCE = TBD (0.50' MIN.)
- C-3 DEFLECT WATER UNDER
DRAINAGE W/ 45° BENDS
PROP. FINISHED GRADE = 14.21
BOTTOM 12" HDPE = 10.15
TOP 6" DIP = 8.65
CLEARANCE = 1.50'
- C-4 DEFLECT WATER UNDER
DRAINAGE W/ 45° BENDS
PROP. FINISHED GRADE = 14.31
BOTTOM 12" HDPE = 10.15
TOP 6" DIP = 8.65
CLEARANCE = 1.50'

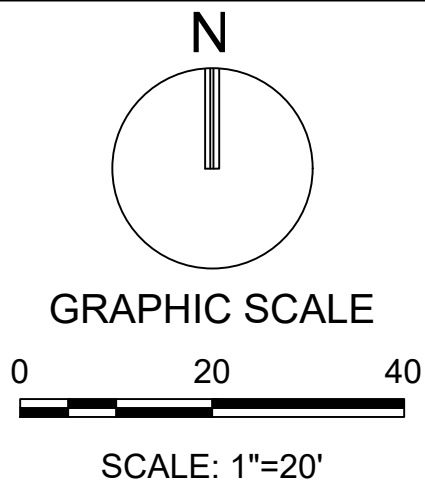

KEITH & ASSOCIATES, INC.
consulting engineers

301 East Atlantic Boulevard
Pompano Beach, Florida 33060-6643

2160 NW 82nd Avenue
Doral, Florida 33122

P: (954) 788-3400 F: (954) 788-3500

Florida Certificate of
Authorization # - 7928

REVISIONS		
NO.	DESCRIPTION	DATE
1	PER DRC COMMENTS	6/8/2017
2	PER DRC COMMENTS	8/24/17
3	PER CITY COMMENTS	12/28/2017
4	PER CITY COMMENTS	5/21/2018

LEDER HILLSBORO STORAGE

SCALE:	AS NOTED
DATE ISSUED:	JANUARY 31, 2018
DRAWN BY:	MG
DESIGNED BY:	MG
CHECKED BY:	SW

STEPHEN D. WILLIAMS, P.E.
FLORIDA REG. NO. 32090
(FOR THE FIRM)

WATER AND SEWER PLAN

SHEET NUMBER
CU-101

SHEET **16** of **27**


PROJECT NO. **09675.00**

THE PRESENCE OF GROUNDWATER SHOULD BE ANTICIPATED. CONTRACTOR'S BID SHALL INCLUDE CONSIDERATION FOR ADDRESSING THIS ISSUE AND OBTAINING ALL NECESSARY PERMITS.

CONTRACTOR TO VERIFY SIZE AND LOCATION OF ALL EXISTING UTILITIES

ALL EXISTING AND PROPOSED ELEVATIONS SHOWN ARE BASED ON NAVD 1988

Drawing name: R:\0909675.00 - Hill Lodge - Leder Group\Engineering\CU-101.dwg Layout Name: CU-101 Plotted on: Jun 15, 2018 - 10:10am Plotted by: MGRink

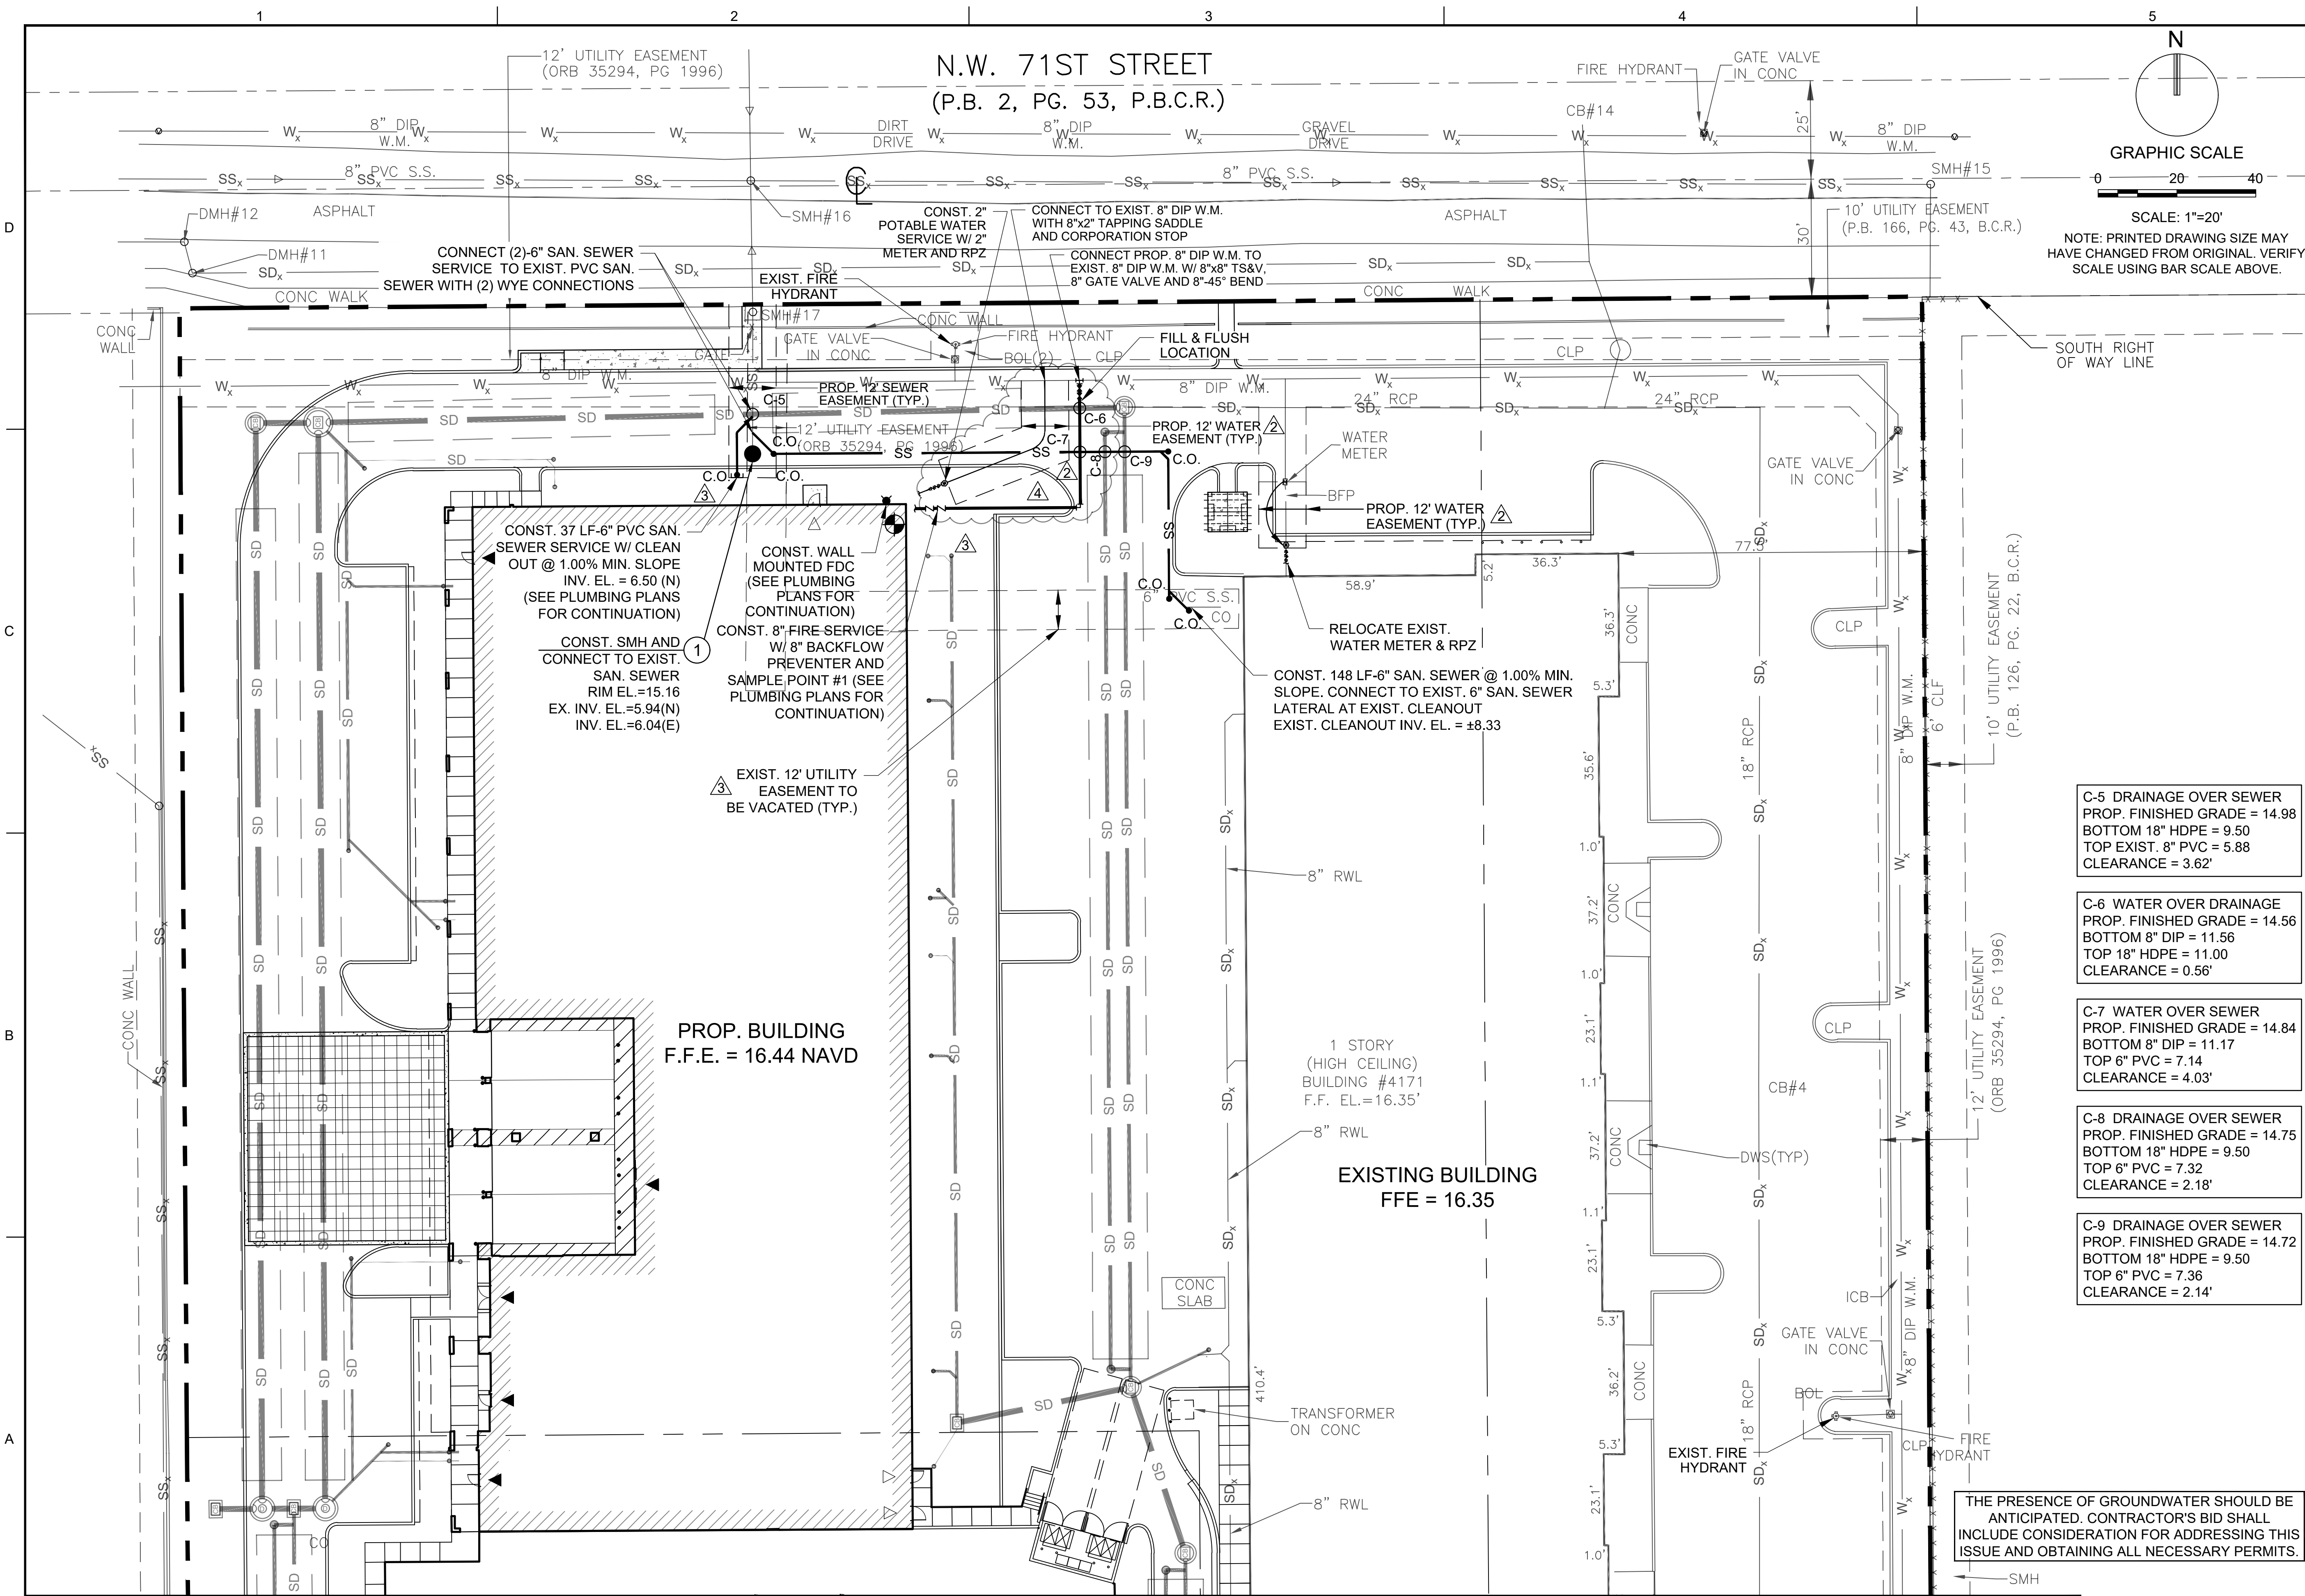

KEITH & ASSOCIATES, INC.
consulting engineers

301 East Atlantic Boulevard
Pompano Beach, Florida 33060-6643

2160 NW 82nd Avenue
Doral, Florida 33122

P: (954) 788-3400 F: (954) 788-3500

Florida Certificate of
Authorization # - 7928

BID / CONTRACT NO. :

REVISIONS		
NO.	DESCRIPTION	DATE
1	PER DRC COMMENTS	6/8/2017
2	PER DRC COMMENTS	8/24/17
3	PER CITY COMMENTS	12/28/2017
4	PER CITY COMMENTS	5/21/2018

LEDER HILLSBORO STORAGE

SCALE: AS NOTED
DATE ISSUED: JANUARY 31, 2018
DRAWN BY: MG
DESIGNED BY: MG
CHECKED BY: SW

STEPHEN D. WILLIAMS, P.E.
FLORIDA REG. NO. 32090
(FOR THE FIRM)

SHEET TITLE
WATER AND SEWER PLAN

SHEET NUMBER
CU-102

SHEET 17 of 26

PROJECT NO. 09675.00









MATCH LINE-SEE SHEET CU-102

CONTRACTOR TO VERIFY SIZE AND LOCATION OF ALL EXISTING UTILITIES

ALL EXISTING AND PROPOSED ELEVATIONS SHOWN ARE BASED ON NAVD 1988

THE PRESENCE OF GROUNDWATER SHOULD BE ANTICIPATED. CONTRACTOR'S BID SHALL INCLUDE CONSIDERATION FOR ADDRESSING THIS ISSUE AND OBTAINING ALL NECESSARY PERMITS.

Drawing name: R:\0909675.00 - Pelt Lodge - Leder Group\Engineering\CU\0909675.00-CU-102.dwg Plotted by: MGrainbank Plotted on: Jun 04, 2018 - 12:24pm Layout Name: CU-102

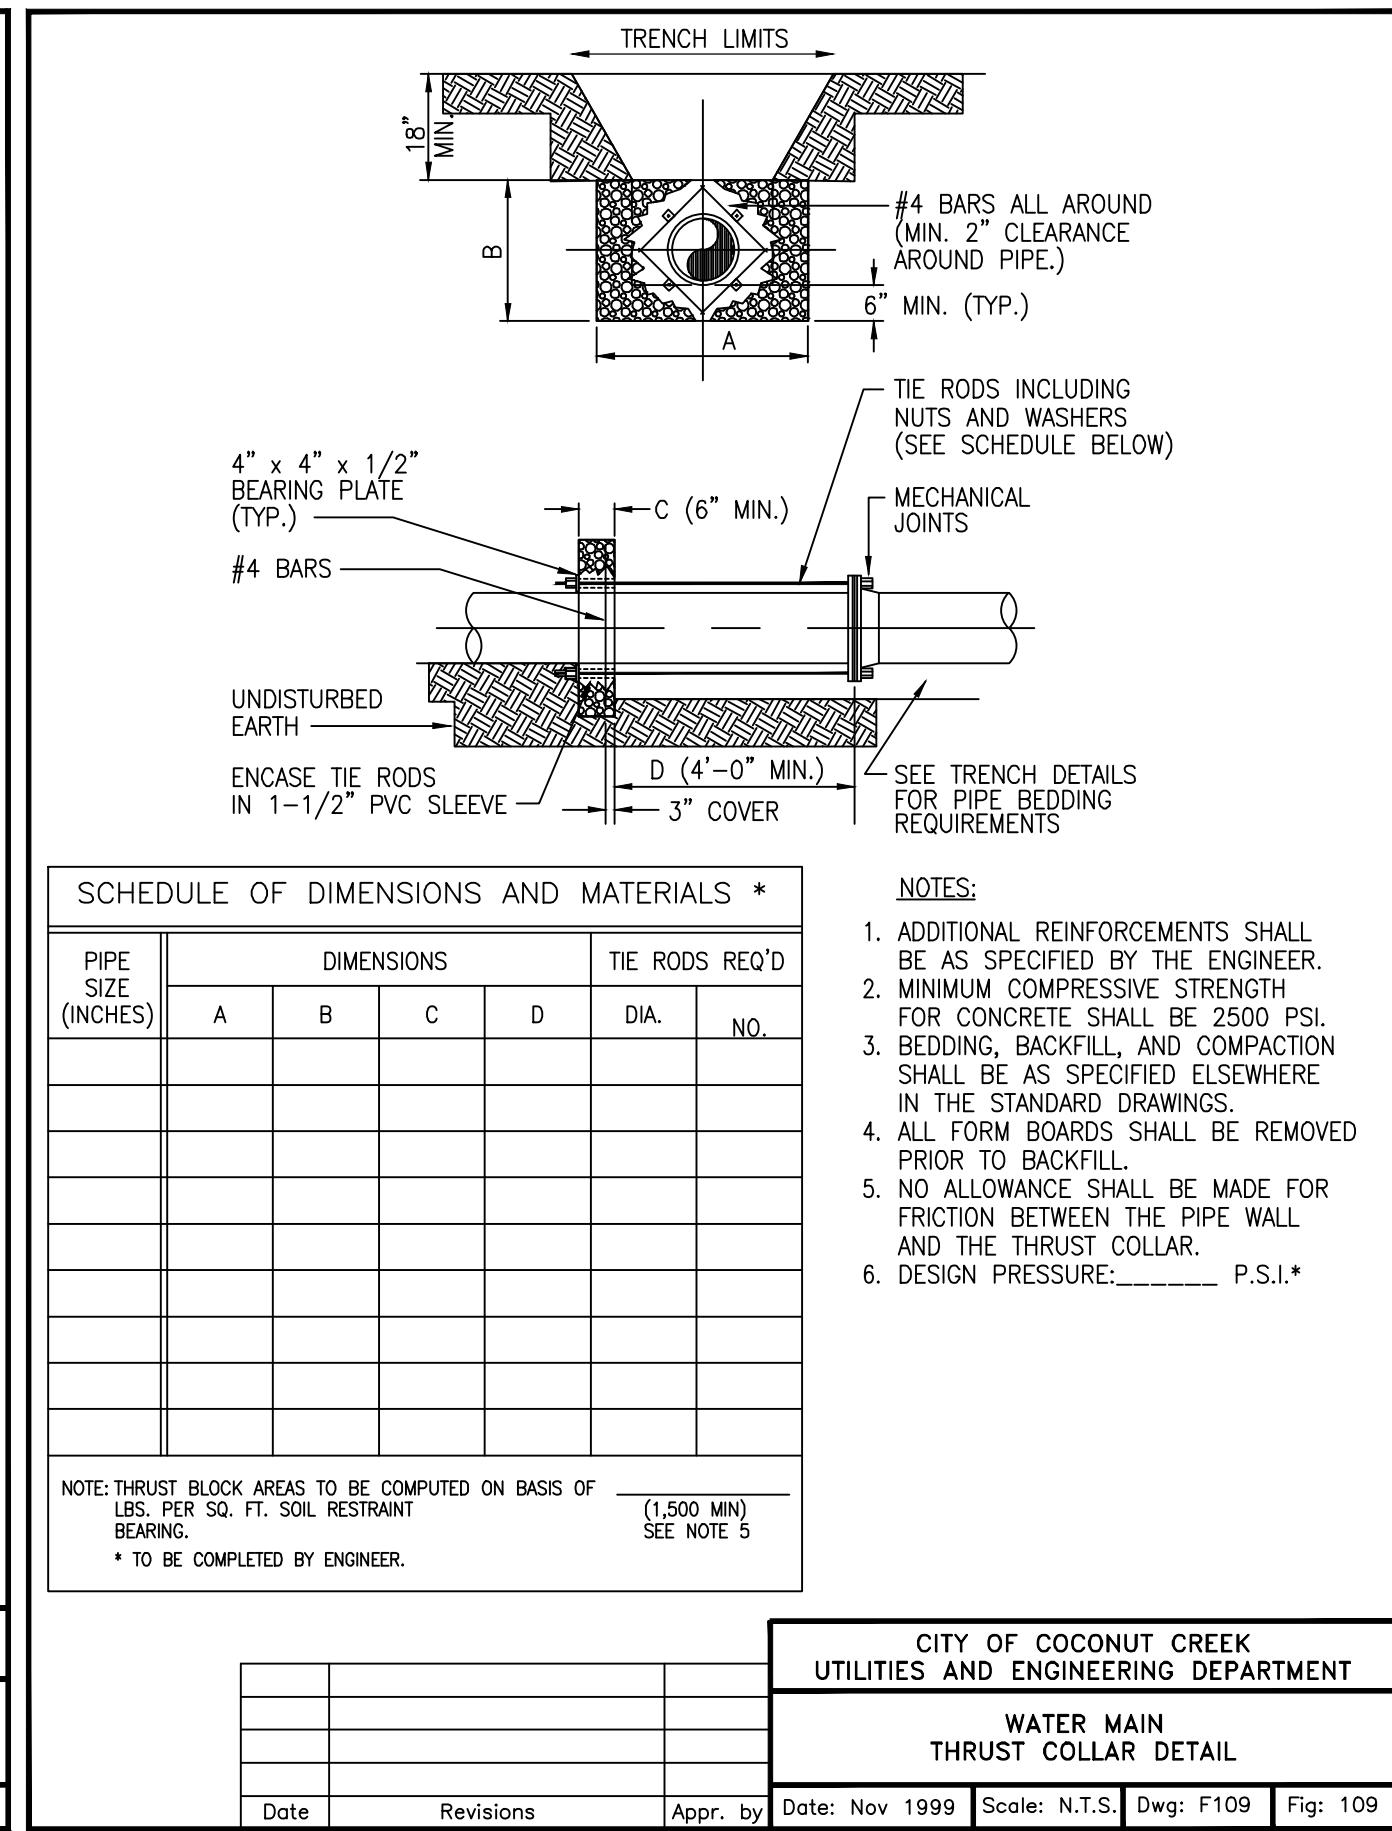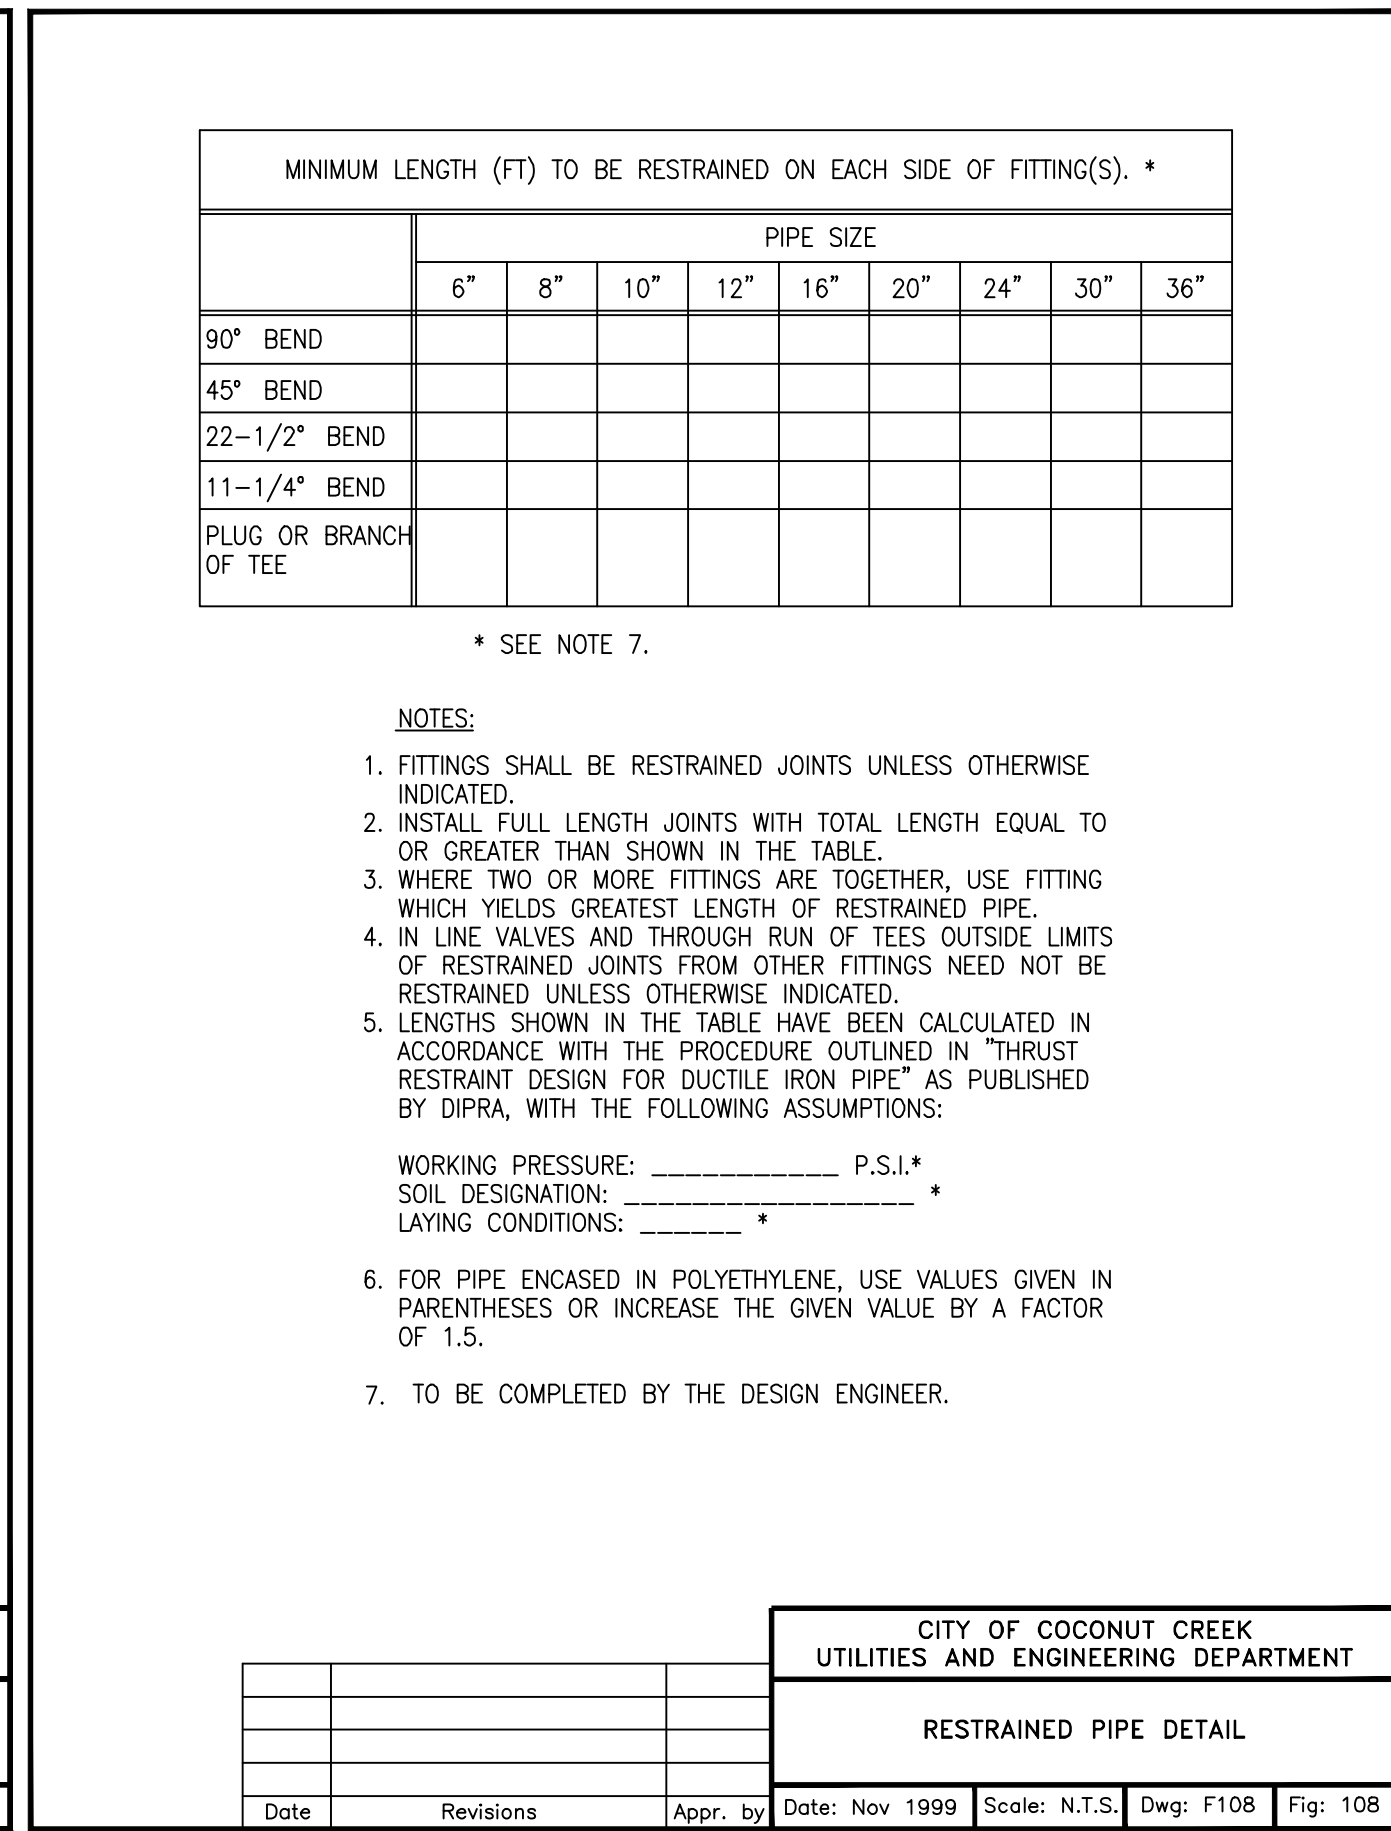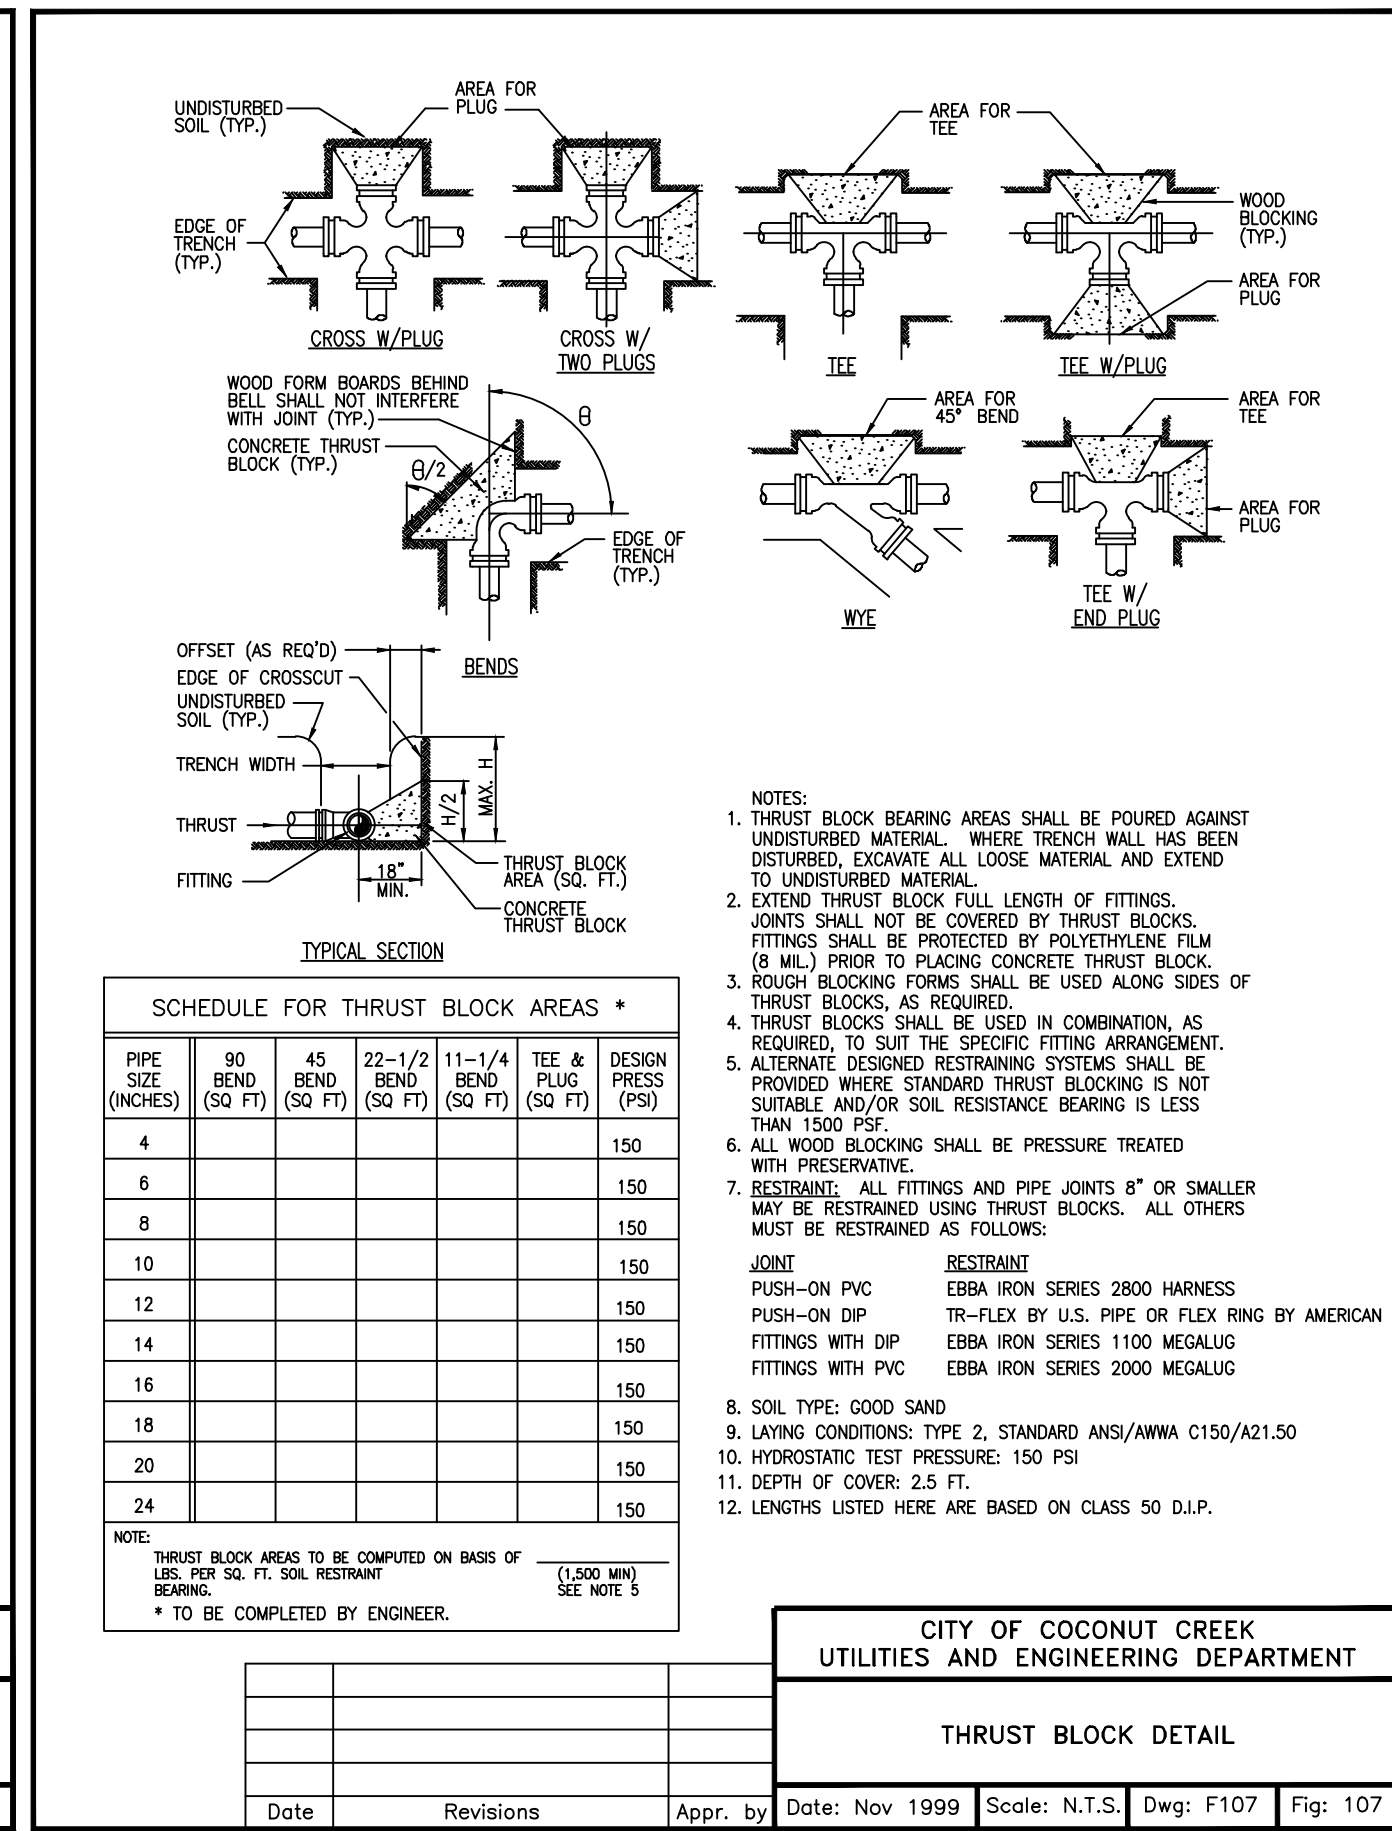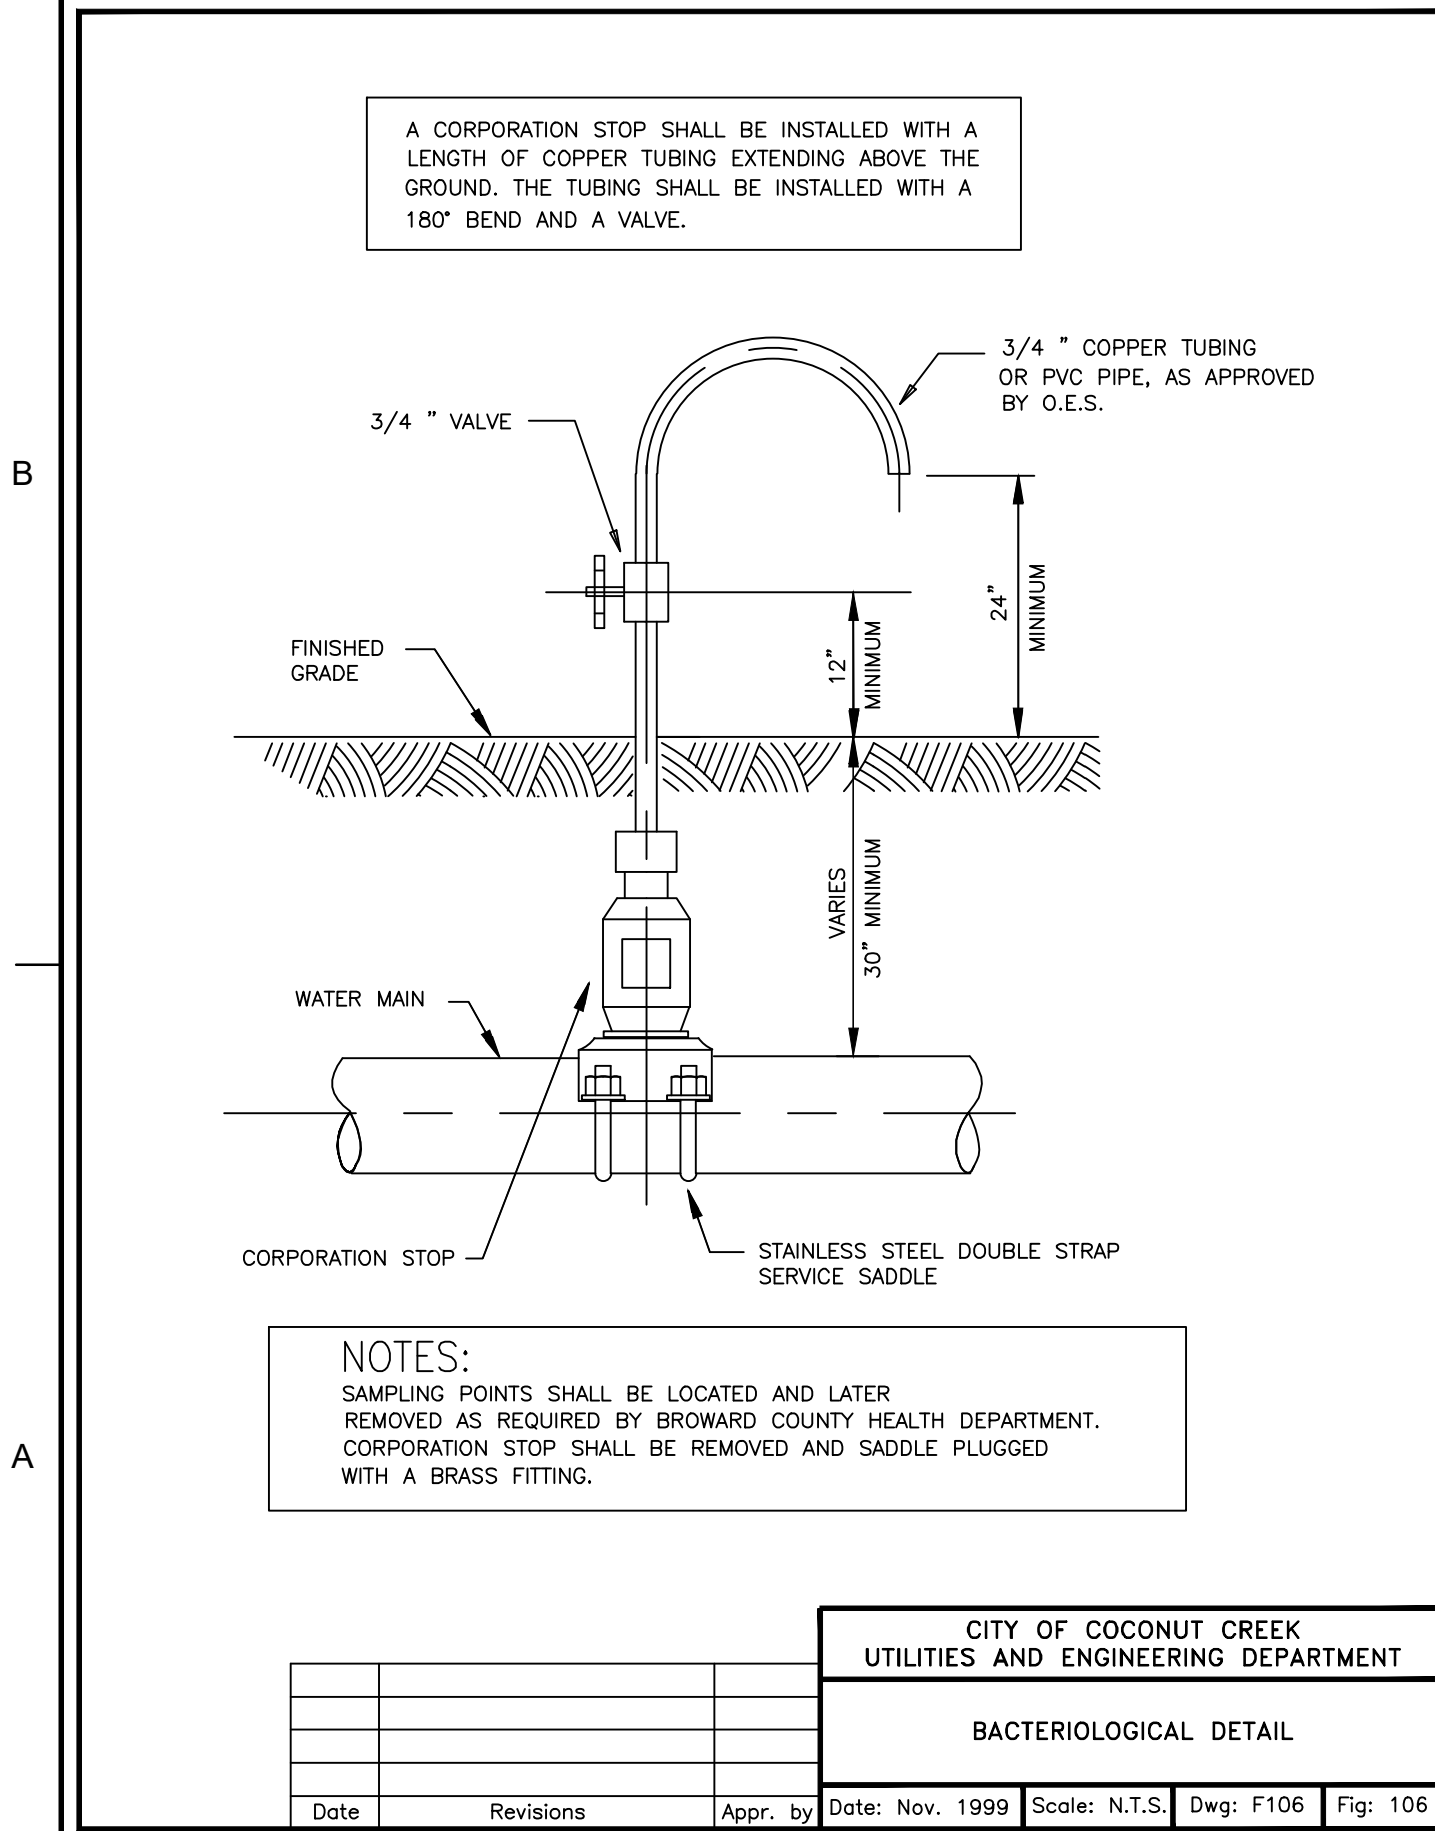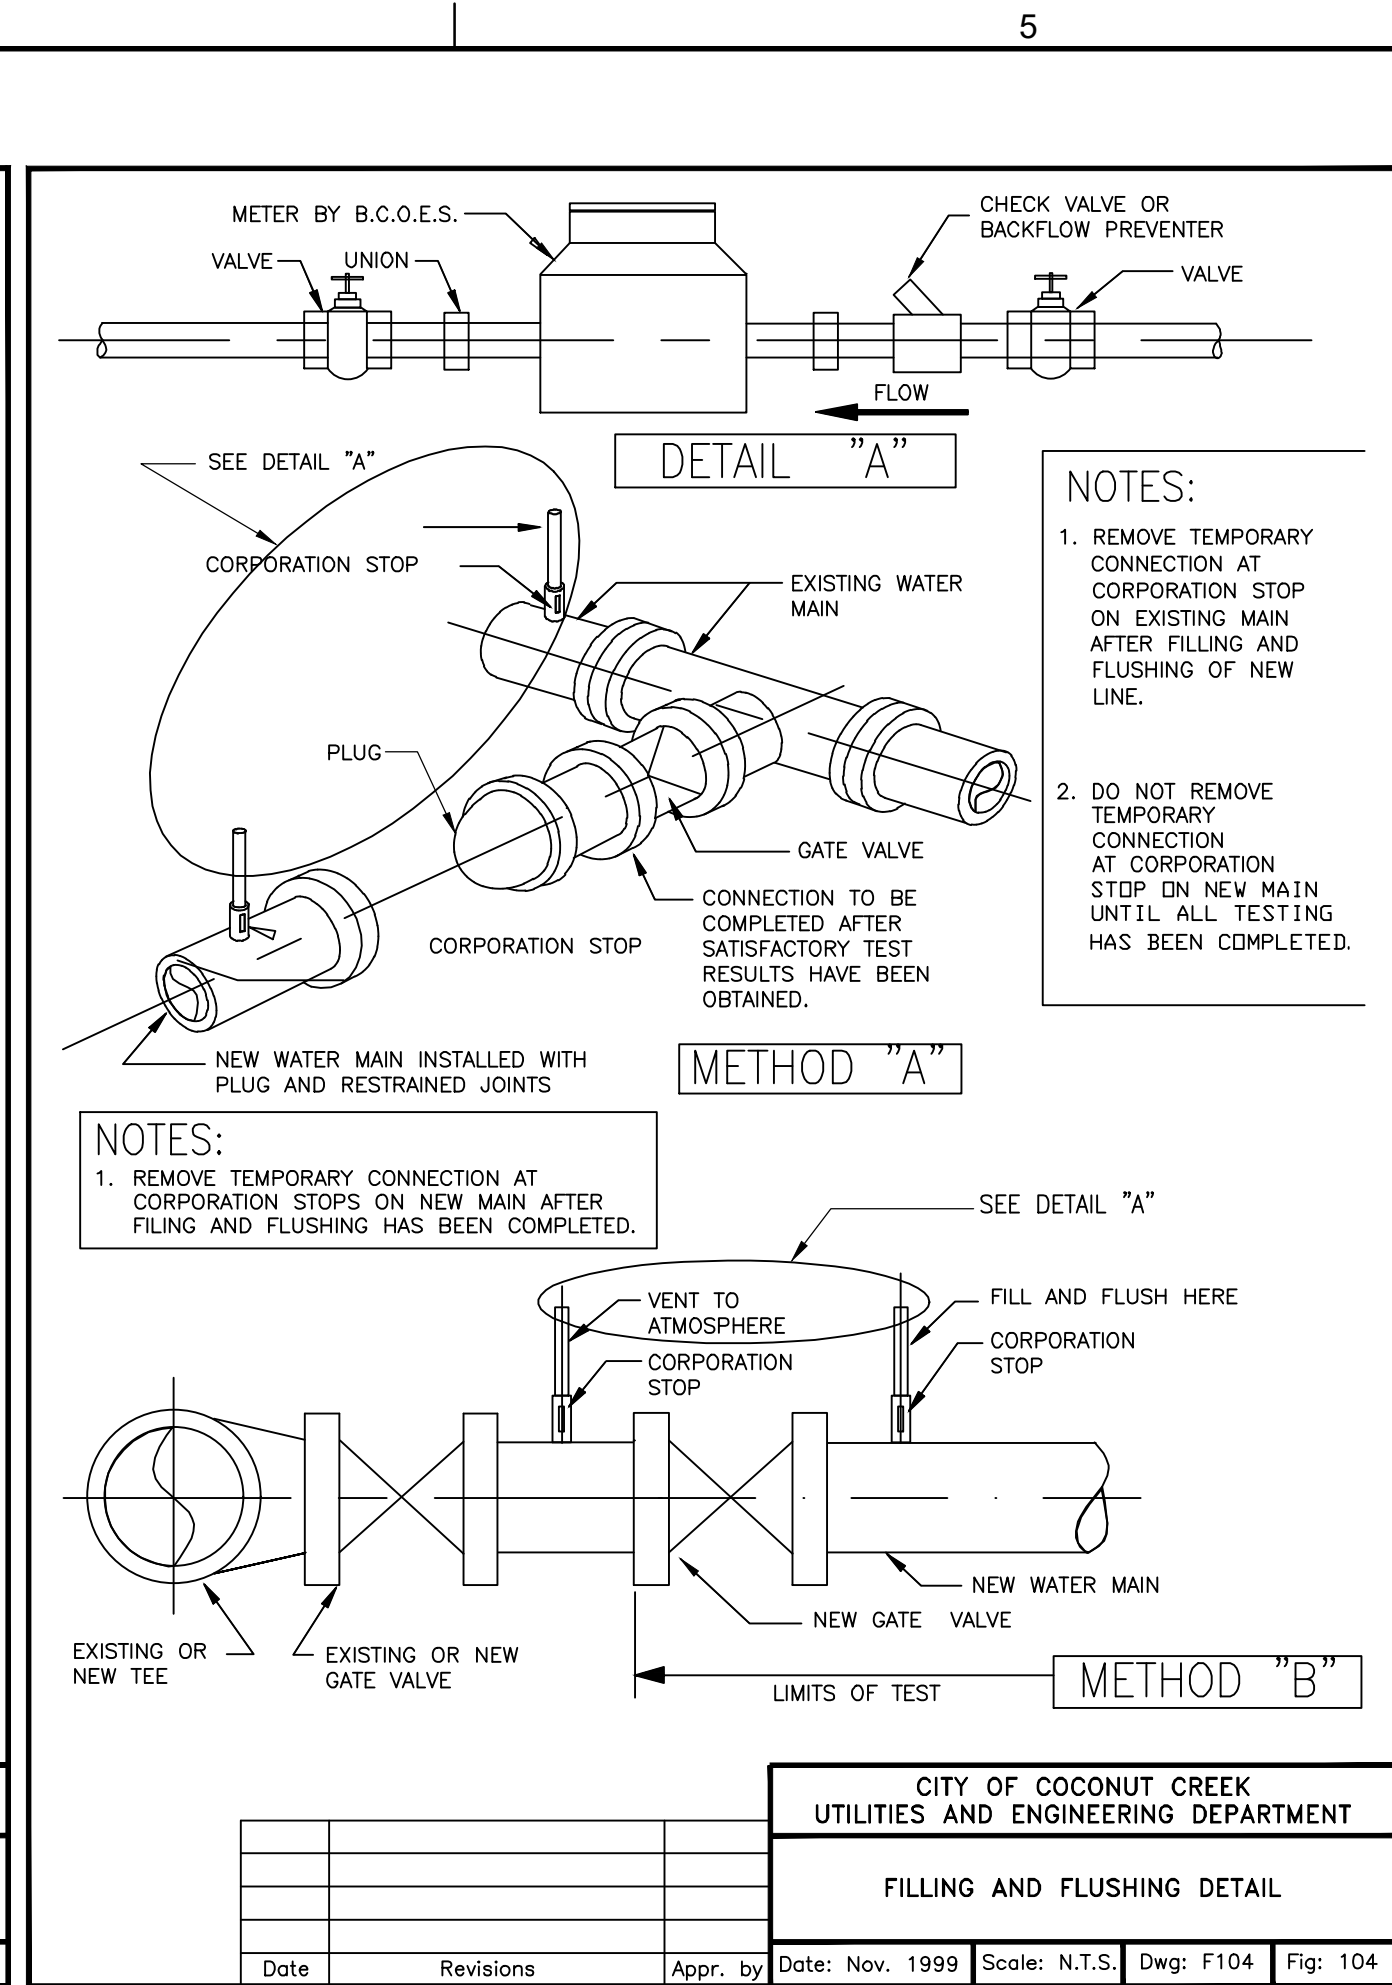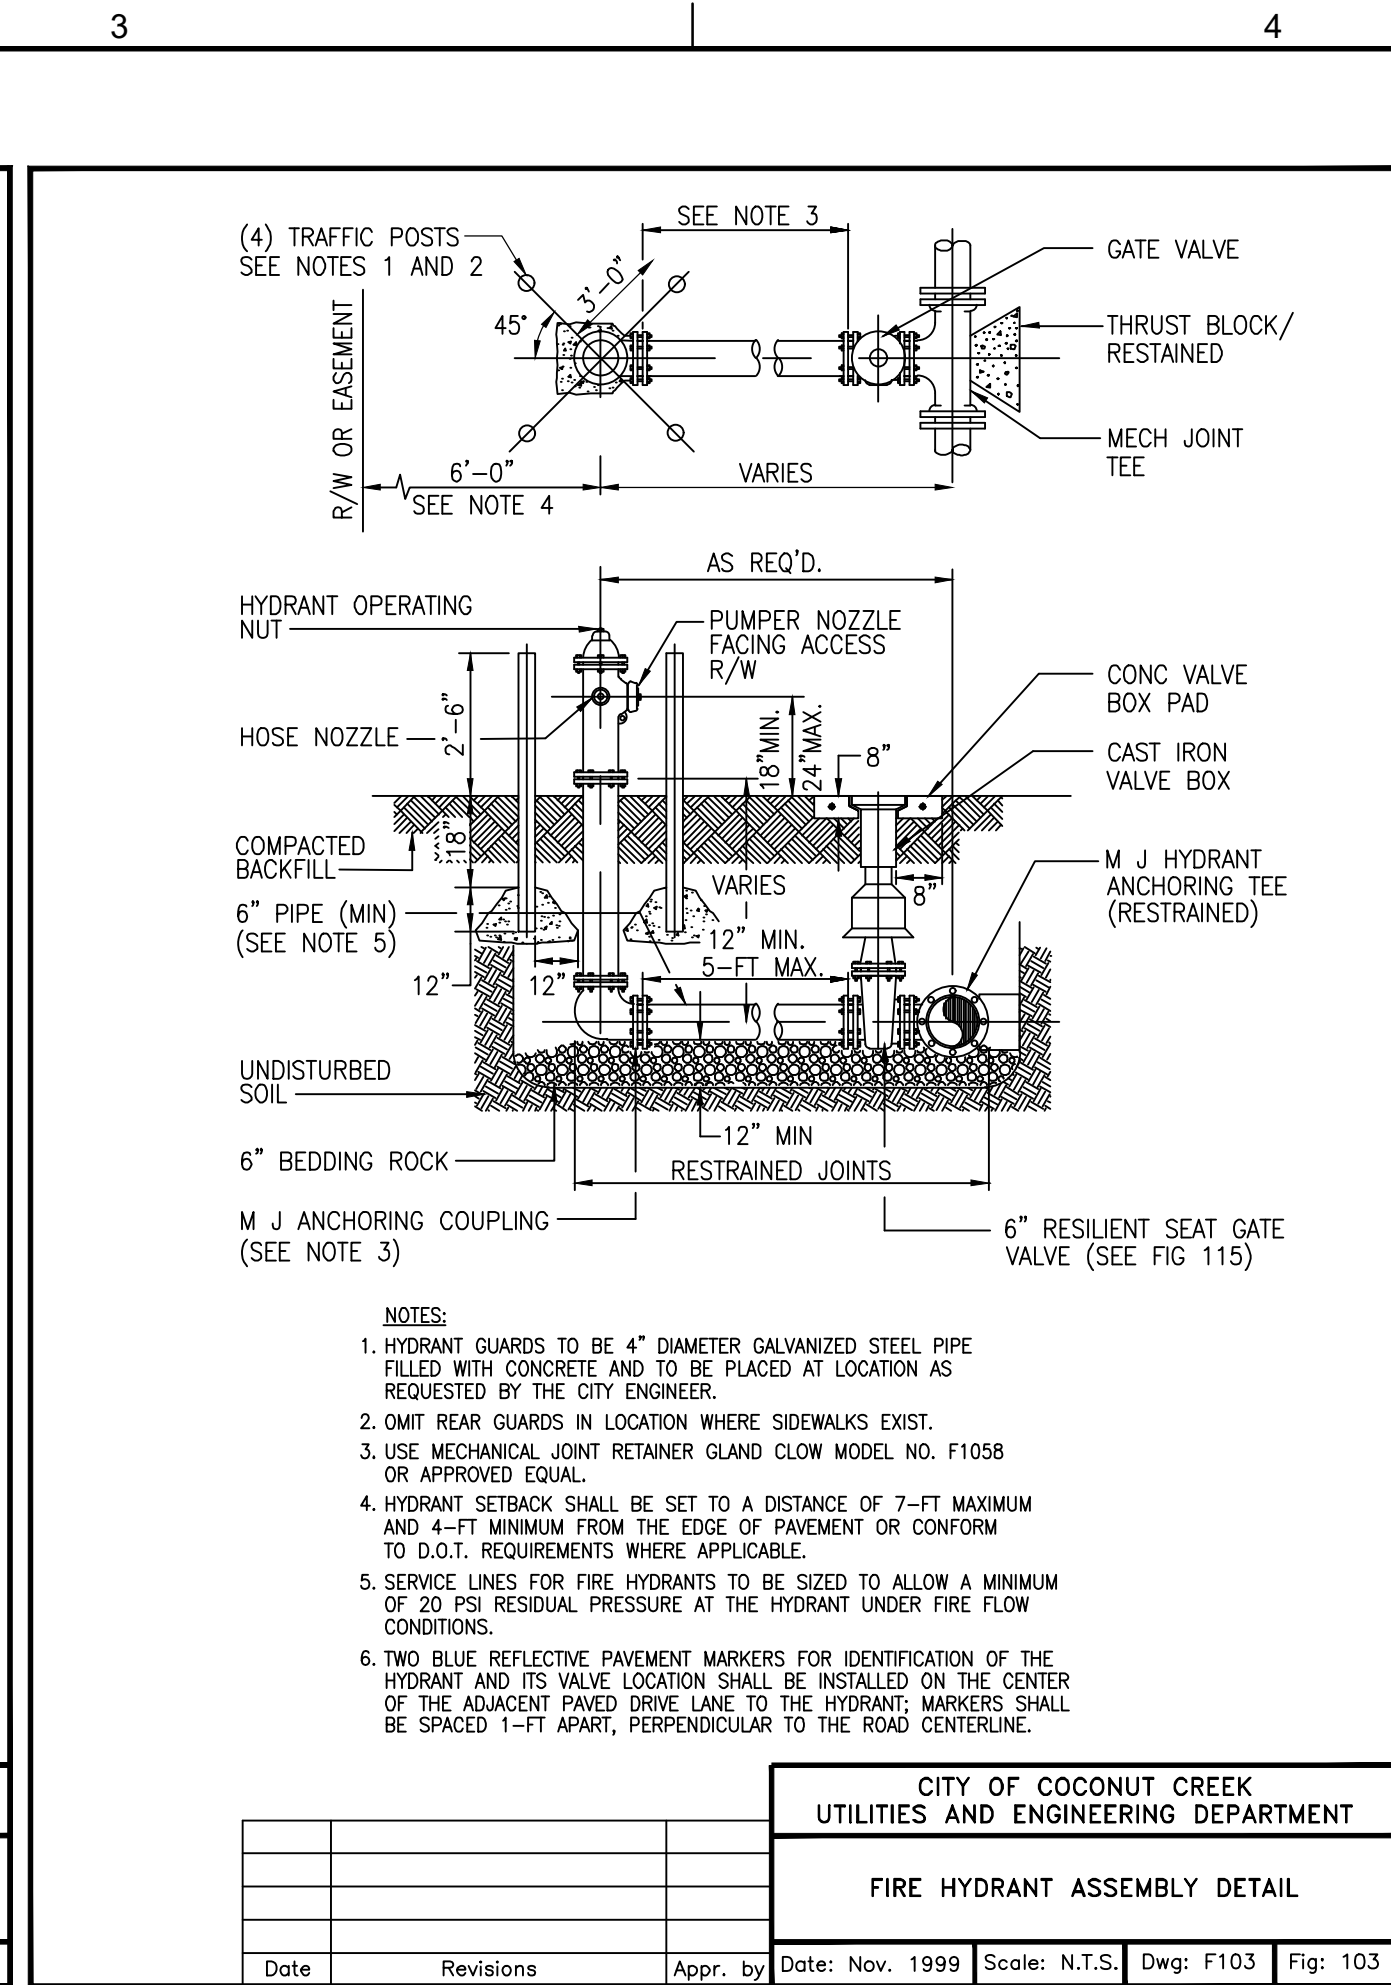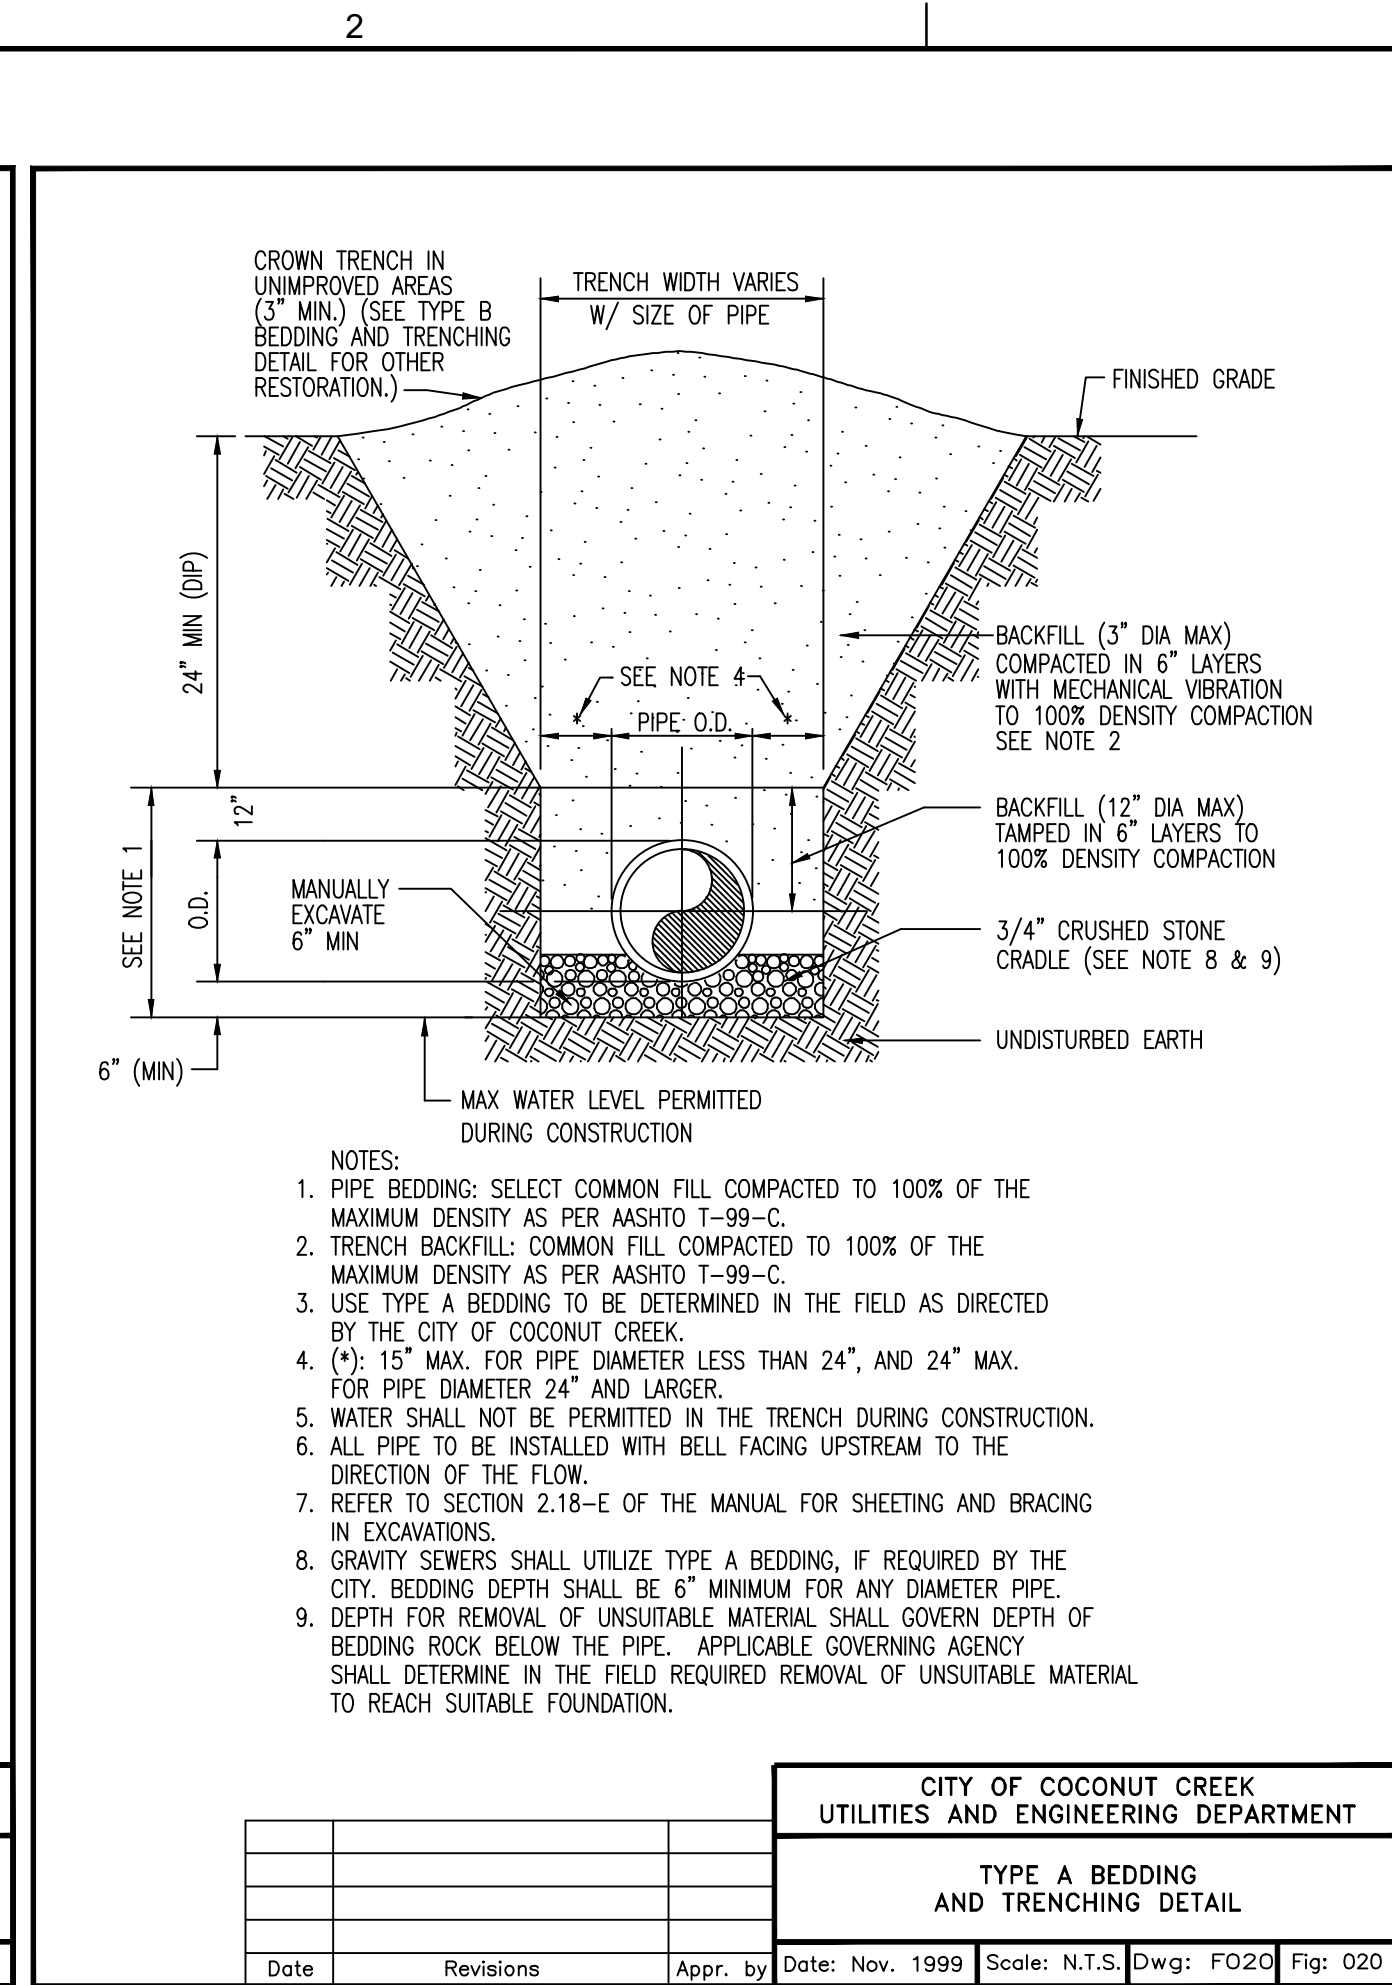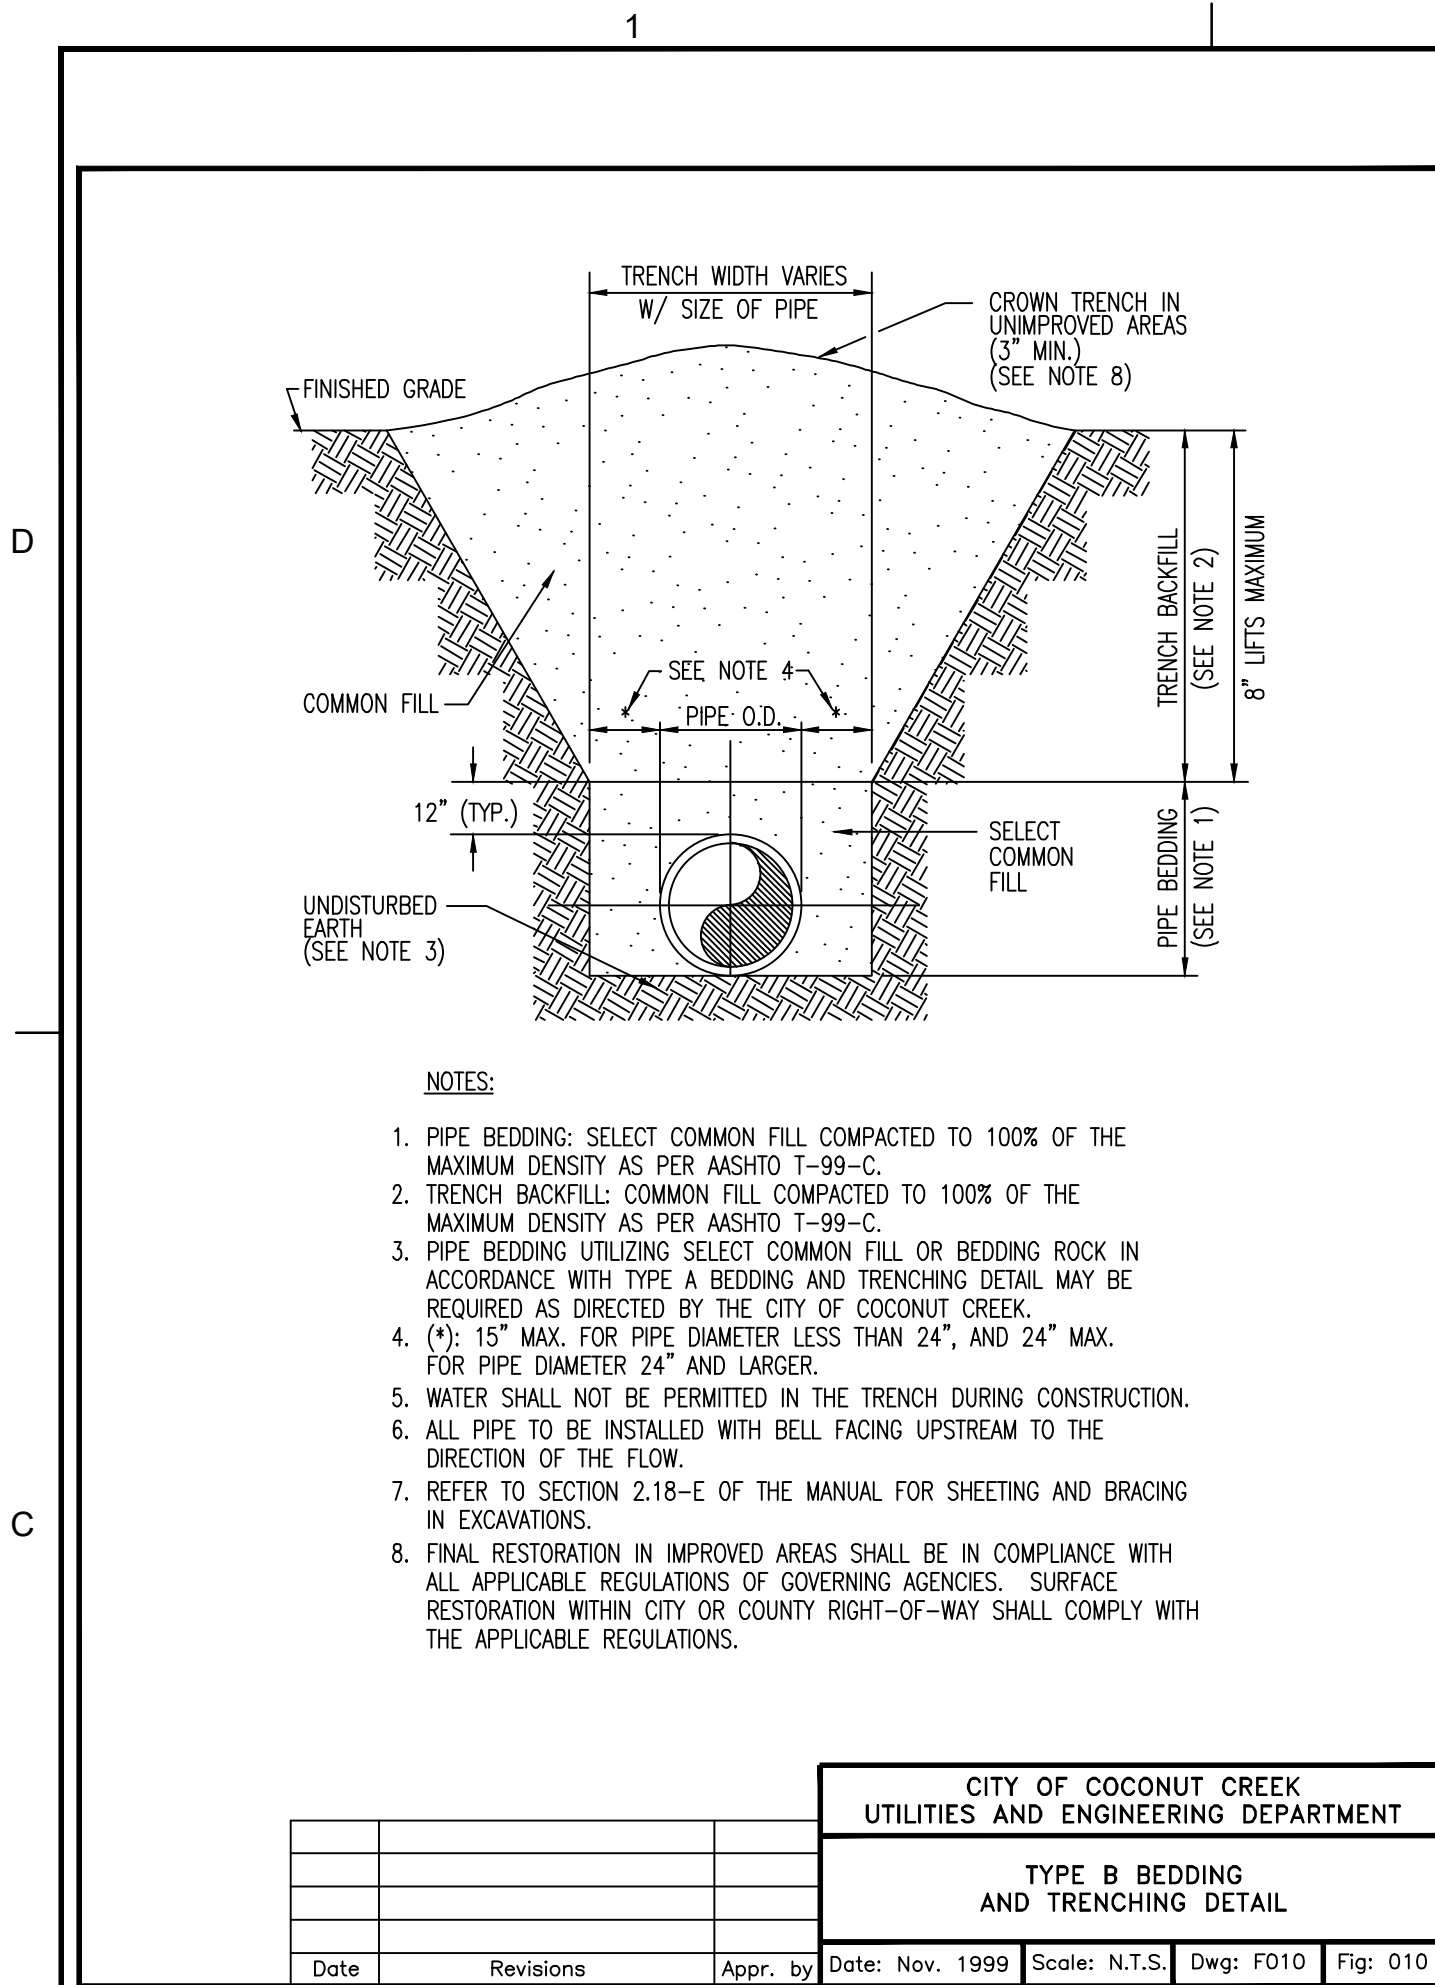

KEITH & ASSOCIATES, INC.
consulting engineers

301 East Atlantic Boulevard
Pompano Beach, Florida 33060-6643

2160 NW 82nd Avenue
Doral, Florida 33122

P: (954) 788-3400 F: (954) 788-3500

Florida Certificate of
Authorization # - 7928

BID / CONTRACT NO. :

REVISIONS

NO.	DESCRIPTION	DATE
1	PER DRC COMMENTS	6/8/2017
2	PER DRC COMMENTS	8/24/17

LEDER
HILLSBORO
STORAGE

SCALE: AS NOTED
DATE ISSUED: JANUARY 31, 2018
DRAWN BY: MG
DESIGNED BY: MG
CHECKED BY: SW

STEPHEN D. WILLIAMS, P.E.
FLORIDA REG. NO. 32090
(FOR THE FIRM)

SHEET TITLE

WATER AND
SEWER DETAILS

SHEET NUMBER
CU-501

SHEET 18 of 26

PROJECT NO. 09675.00

Drawing name: N:\08\0675.00 - Pet Lodge - Leder Group\Engineering\Cadd\0675.00-CM-1XX.dwg Plotted by: MGrinbank Plotted on: Jun 18, 2018 - 11:42am



Corporate Office
301 East Atlantic Boulevard
Pompano Beach, Florida 33060-6643
(954) 788-3400

Miami-Dade County
2160 NW 82 Avenue
Doral, Florida 33122

Palm Beach County
120 N Federal Highway, Suite 208
Lake Worth, Florida 33460

Orange County
2948 E Livingston Street
Orlando, Florida 32803

State of Florida Certificate of
Authorization Number - 7928

BID / CONTRACT NO. :

REVISIONS

NO.	DESCRIPTION	DATE
1	PER DRC COMMENTS	6/8/2017
2	PER DRC COMMENTS	8/24/17
3	PER CITY COMMENTS	12/28/2017

LEDER
HILLSBORO
STORAGE

SCALE: AS NOTED

DATE ISSUED: JANUARY 31, 2018

DRAWN BY: MG

DESIGNED BY: MG

CHECKED BY: SW

STEPHEN D. WILLIAMS, P.E.
FLORIDA REG. NO. 32090
(FOR THE FIRM)

SHEET TITLE

PAVEMENT MARKING
AND SIGNAGE PLAN

SHEET NUMBER

CM-102


SHEET 23 of 27

PROJECT NO. 09675.00

N.W. 71ST STREET
(P.B. 2, PG. 53, P.B.C.R.)

NOTES:

1. ALL SIGNS SHALL USE TYPE XI SHEETING.
2. ANY PAVEMENT MARKINGS OR SIGNS DAMAGED DURING CONSTRUCTION SHALL BE RESTORED ACCORDING TO BROWARD COUNTY TRAFFIC ENGINEERING STANDARDS.

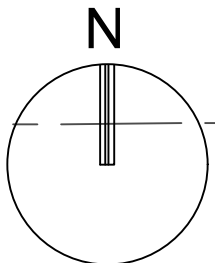

GRAPHIC SCALE

0 20' 40'

SCALE: 1"=20'

NOTE: PRINTED DRAWING SIZE MAY
HAVE CHANGED FROM ORIGINAL. VERIFY
SCALE USING BAR SCALE ABOVE.



FIRE LANE SIGN
(12" x 18")



R5-1 DO NOT
ENTER SIGN
(30" x 30")




R3-5R RIGHT
TURN ONLY SIGN
(24" x 30")



R1-1 STOP SIGN
(30" x 30")

SOUTH RIGHT
OF WAY LINE

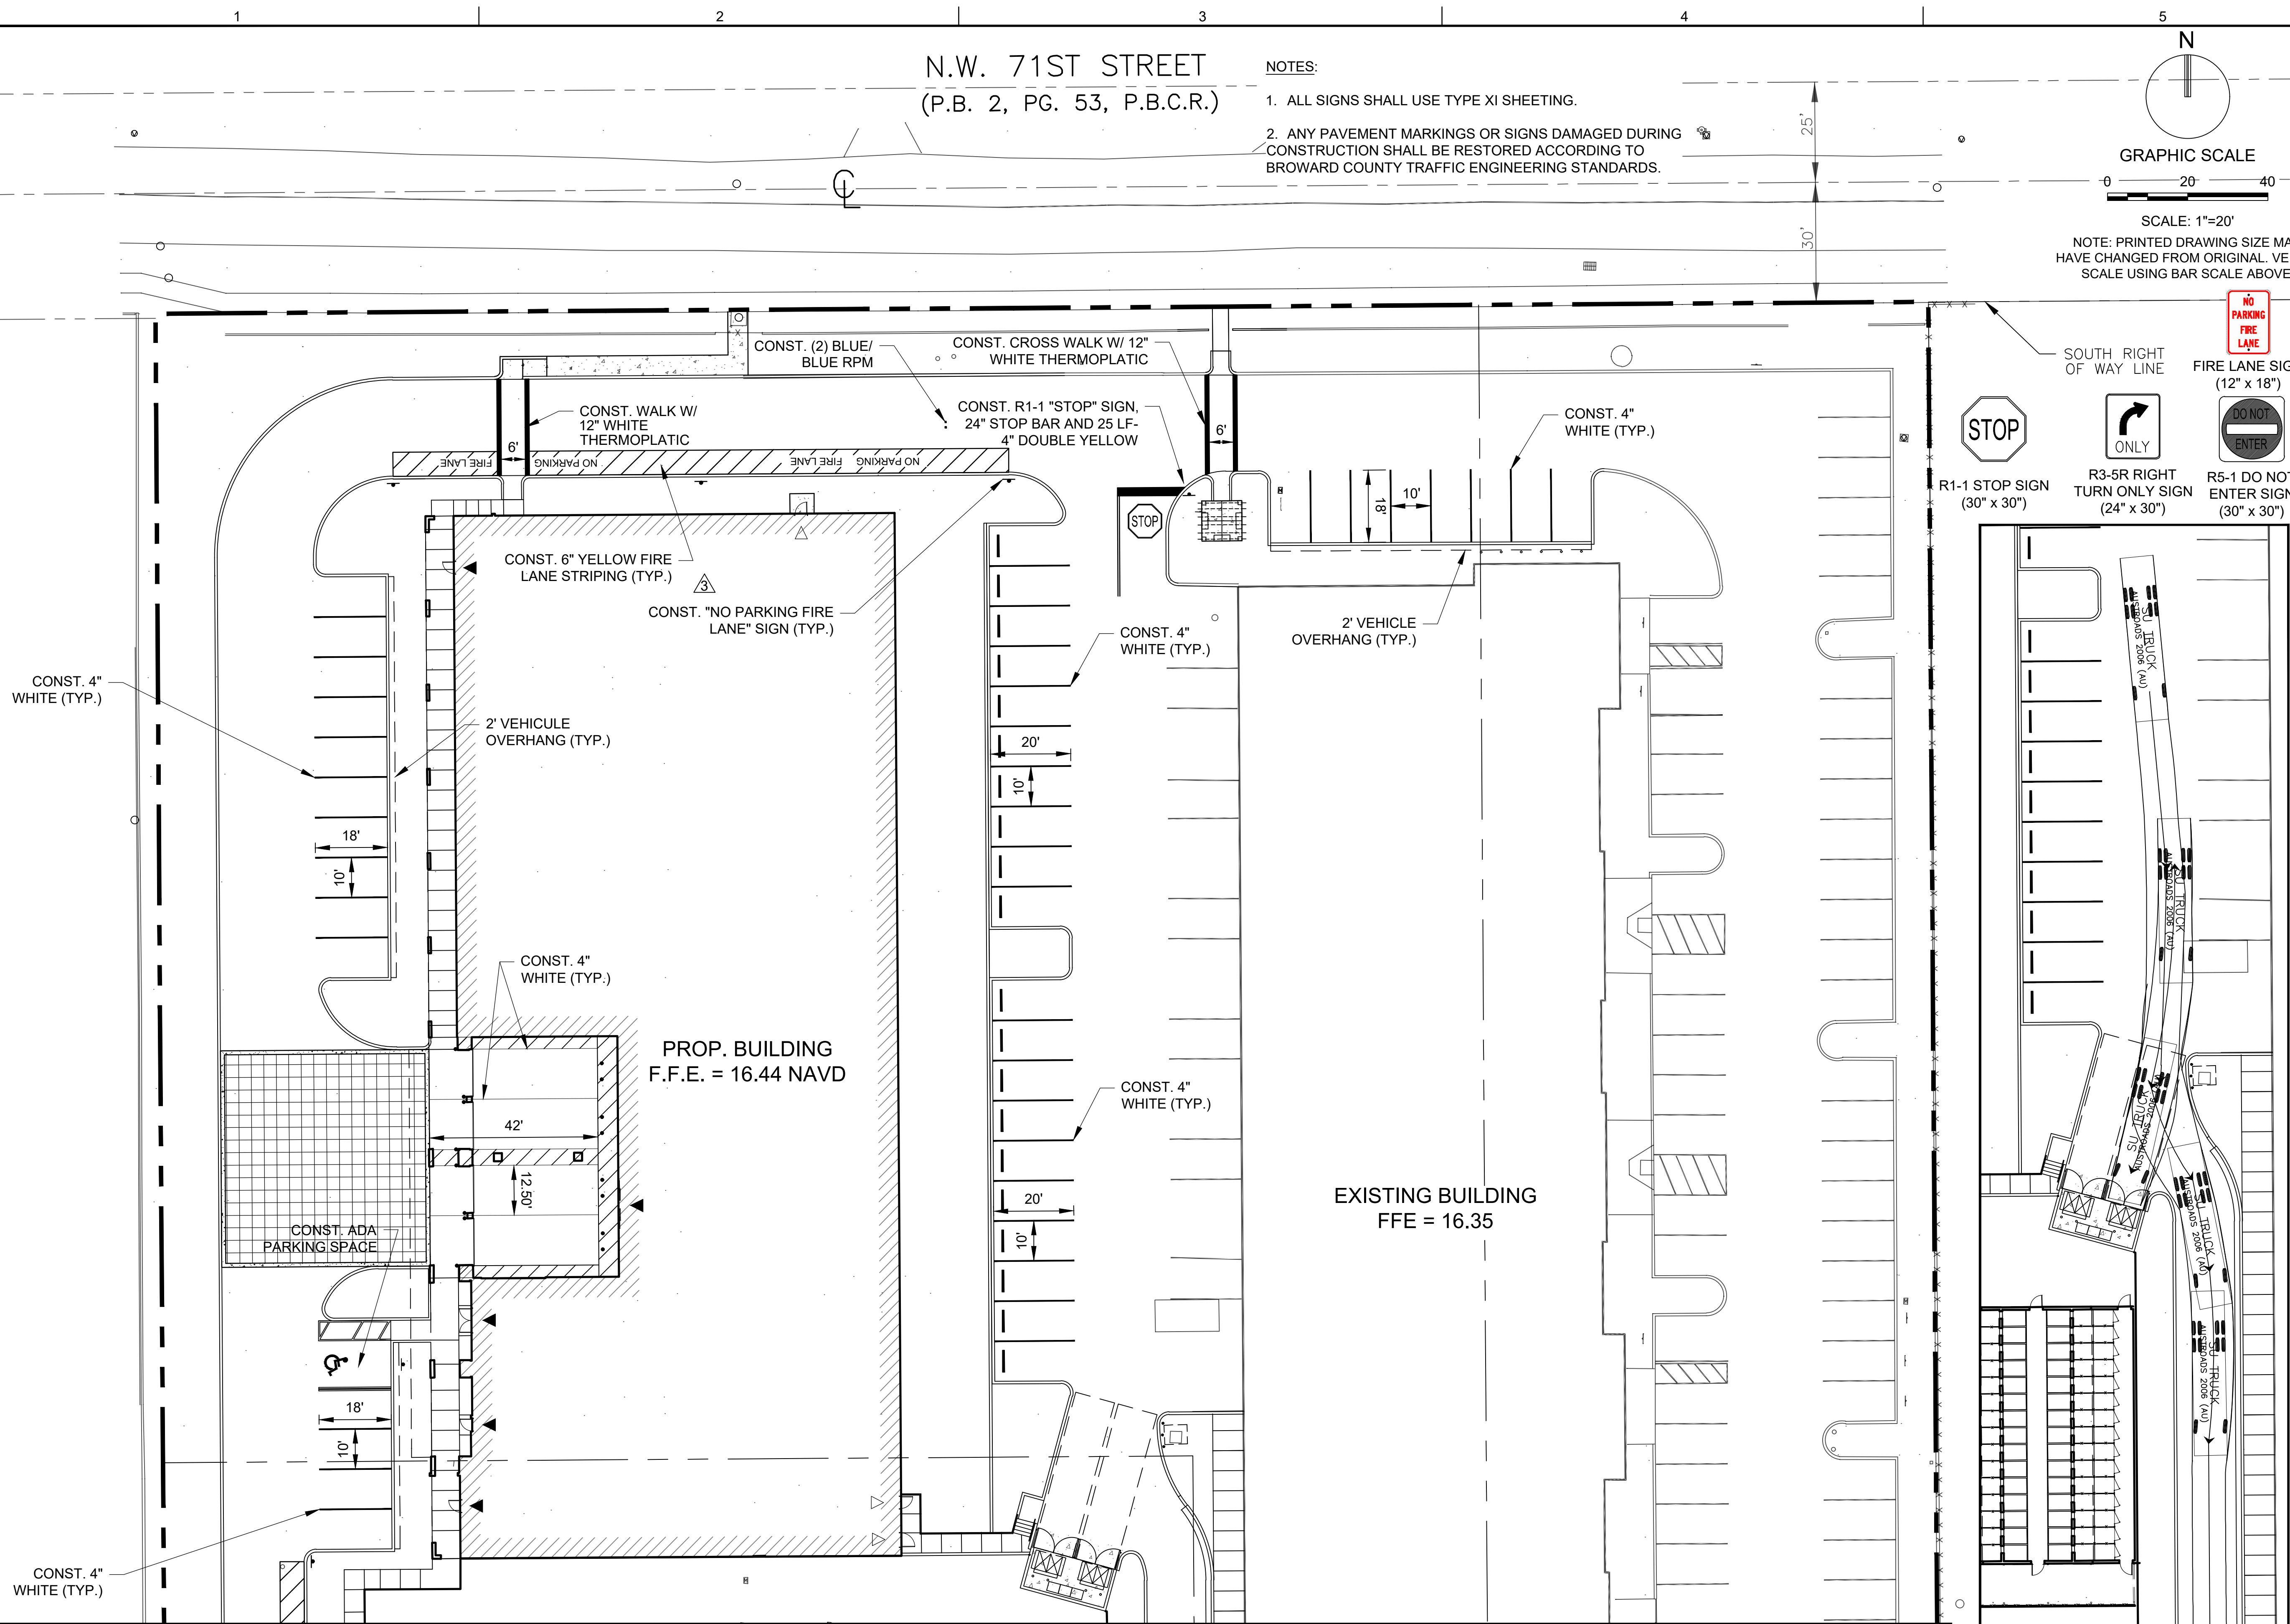

MATCH LINE-SEE SHEET CM-101

REFUSE TRUCK ACCESS EXHIBIT



Corporate Office
301 East Atlantic Boulevard
Pompano Beach, Florida 33060-6643
(954) 788-3400

Miami-Dade County
2160 NW 82 Avenue
Doral, Florida 33122

Palm Beach County
120 N Federal Highway, Suite 208
Lake Worth, Florida 33460

Orange County
2948 E Livingston Street
Orlando, Florida 32803

State of Florida Certificate of
Authorization Number - 7928

BID / CONTRACT NO. :

REVISIONS

NO.	DESCRIPTION	DATE
1	PER DRC COMMENTS	6/8/2017
2	PER DRC COMMENTS	8/24/17
3	PER BCTD COMMENTS	6/11/18

LEDER
HILLSBORO
STORAGE

SCALE: AS NOTED

DATE ISSUED: JANUARY 31, 2018

DRAWN BY: MG

DESIGNED BY: MG

CHECKED BY: SW

STEPHEN D. WILLIAMS, P.E.
FLORIDA REG. NO. 32090
(FOR THE FIRM)

SHEET TITLE
CITY OF COCONUT CREEK PAVEMENT MARKING AND SIGNAGE DETAILS




SHEET NUMBER
CM-501

SHEET 24 of 27

PROJECT NO. 09675.00

ALL ON-SITE SIGNS SHALL BE IN ACCORDANCE WITH BROWARD COUNTY "STOP SIGN AND STREET IDENTIFICATION ASSEMBLY TYPICAL DETAILS".

ALL SIGNS WITHIN FDOT RIGHT-OF-WAY SHALL BE IN ACCORDANCE WITH FDOT INDEX 11860

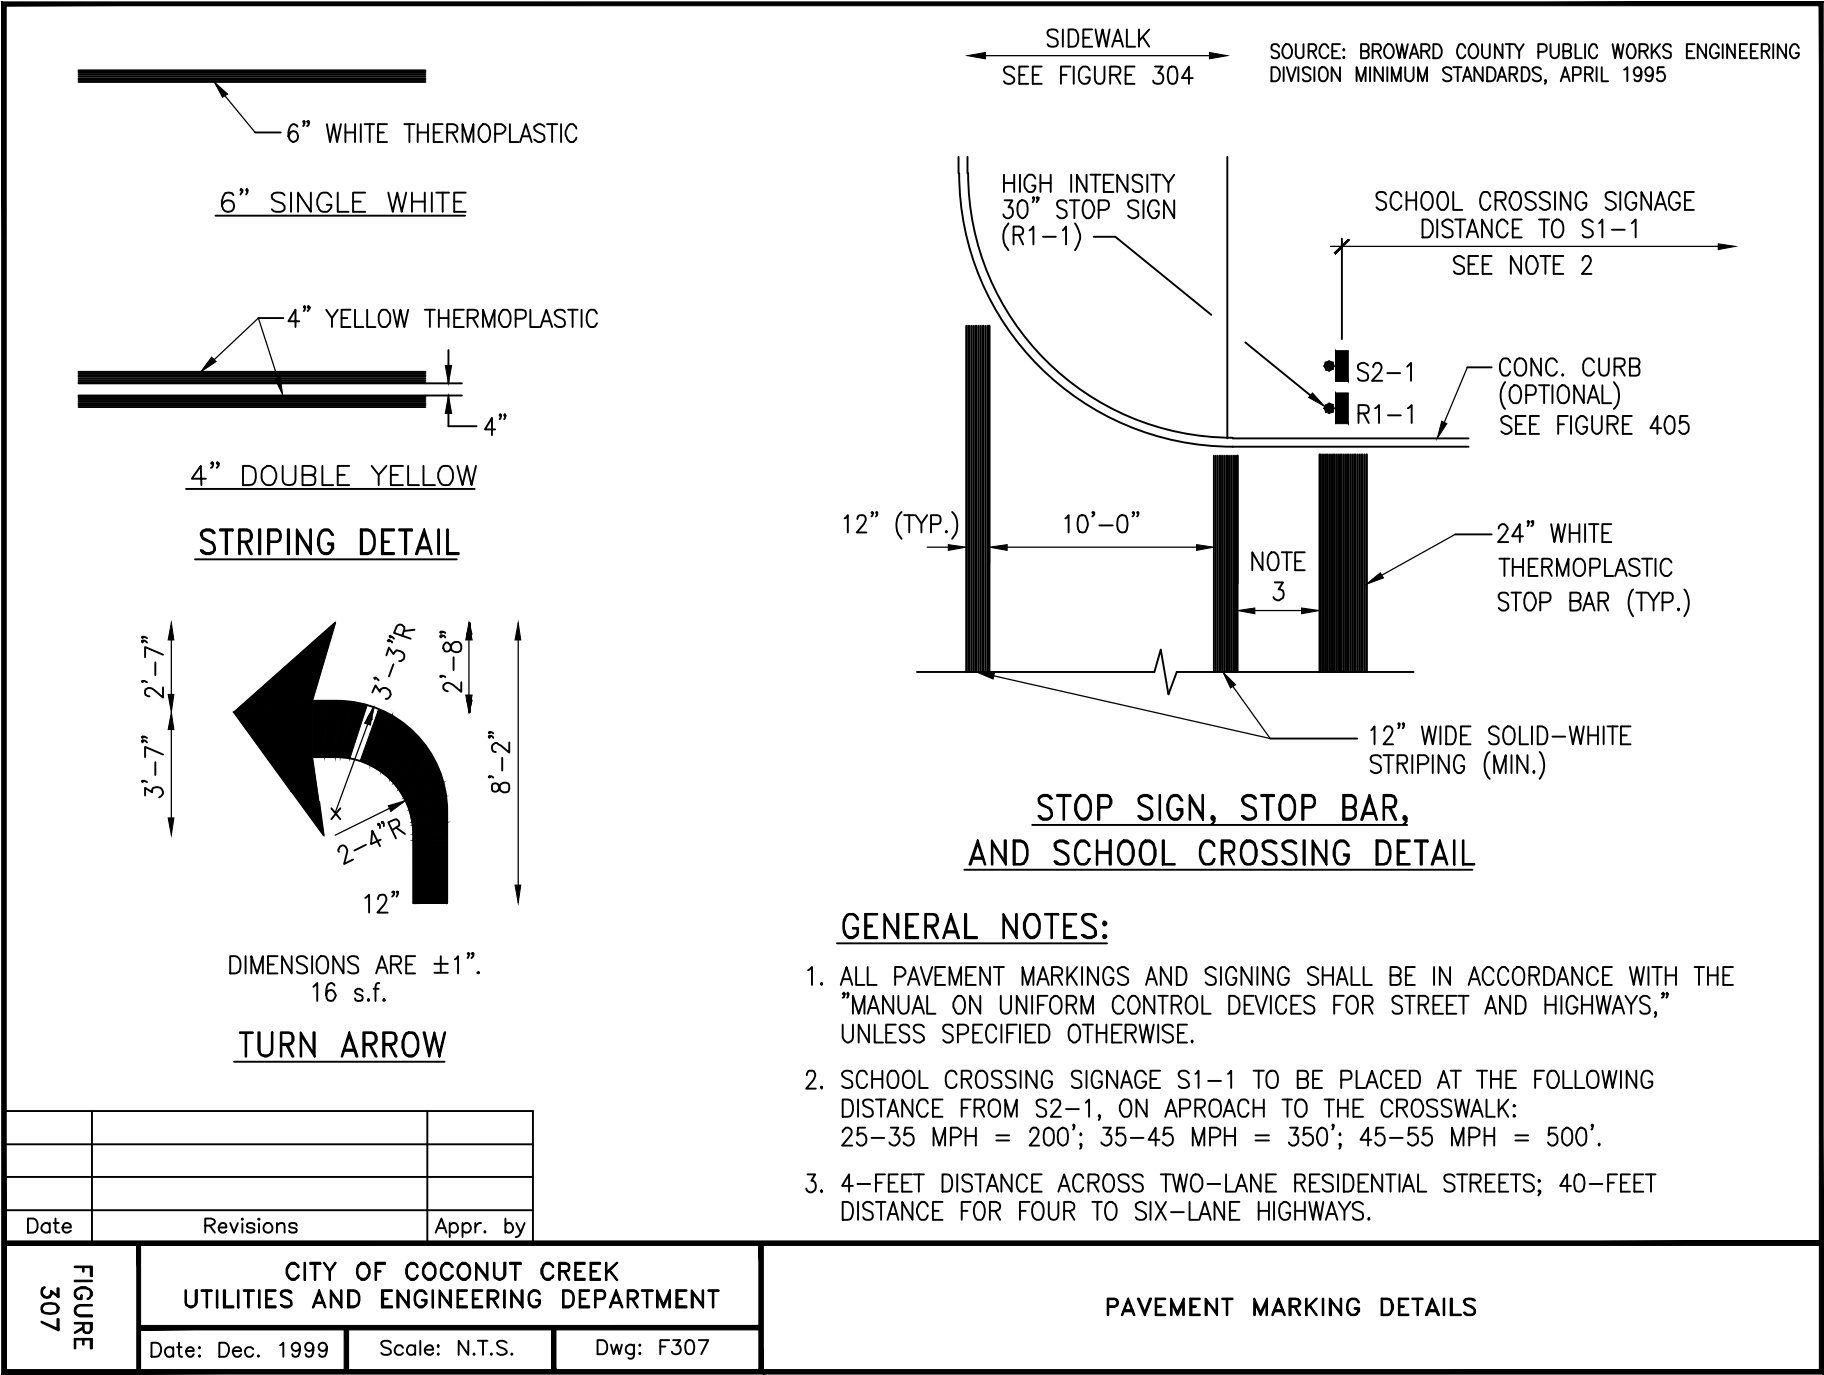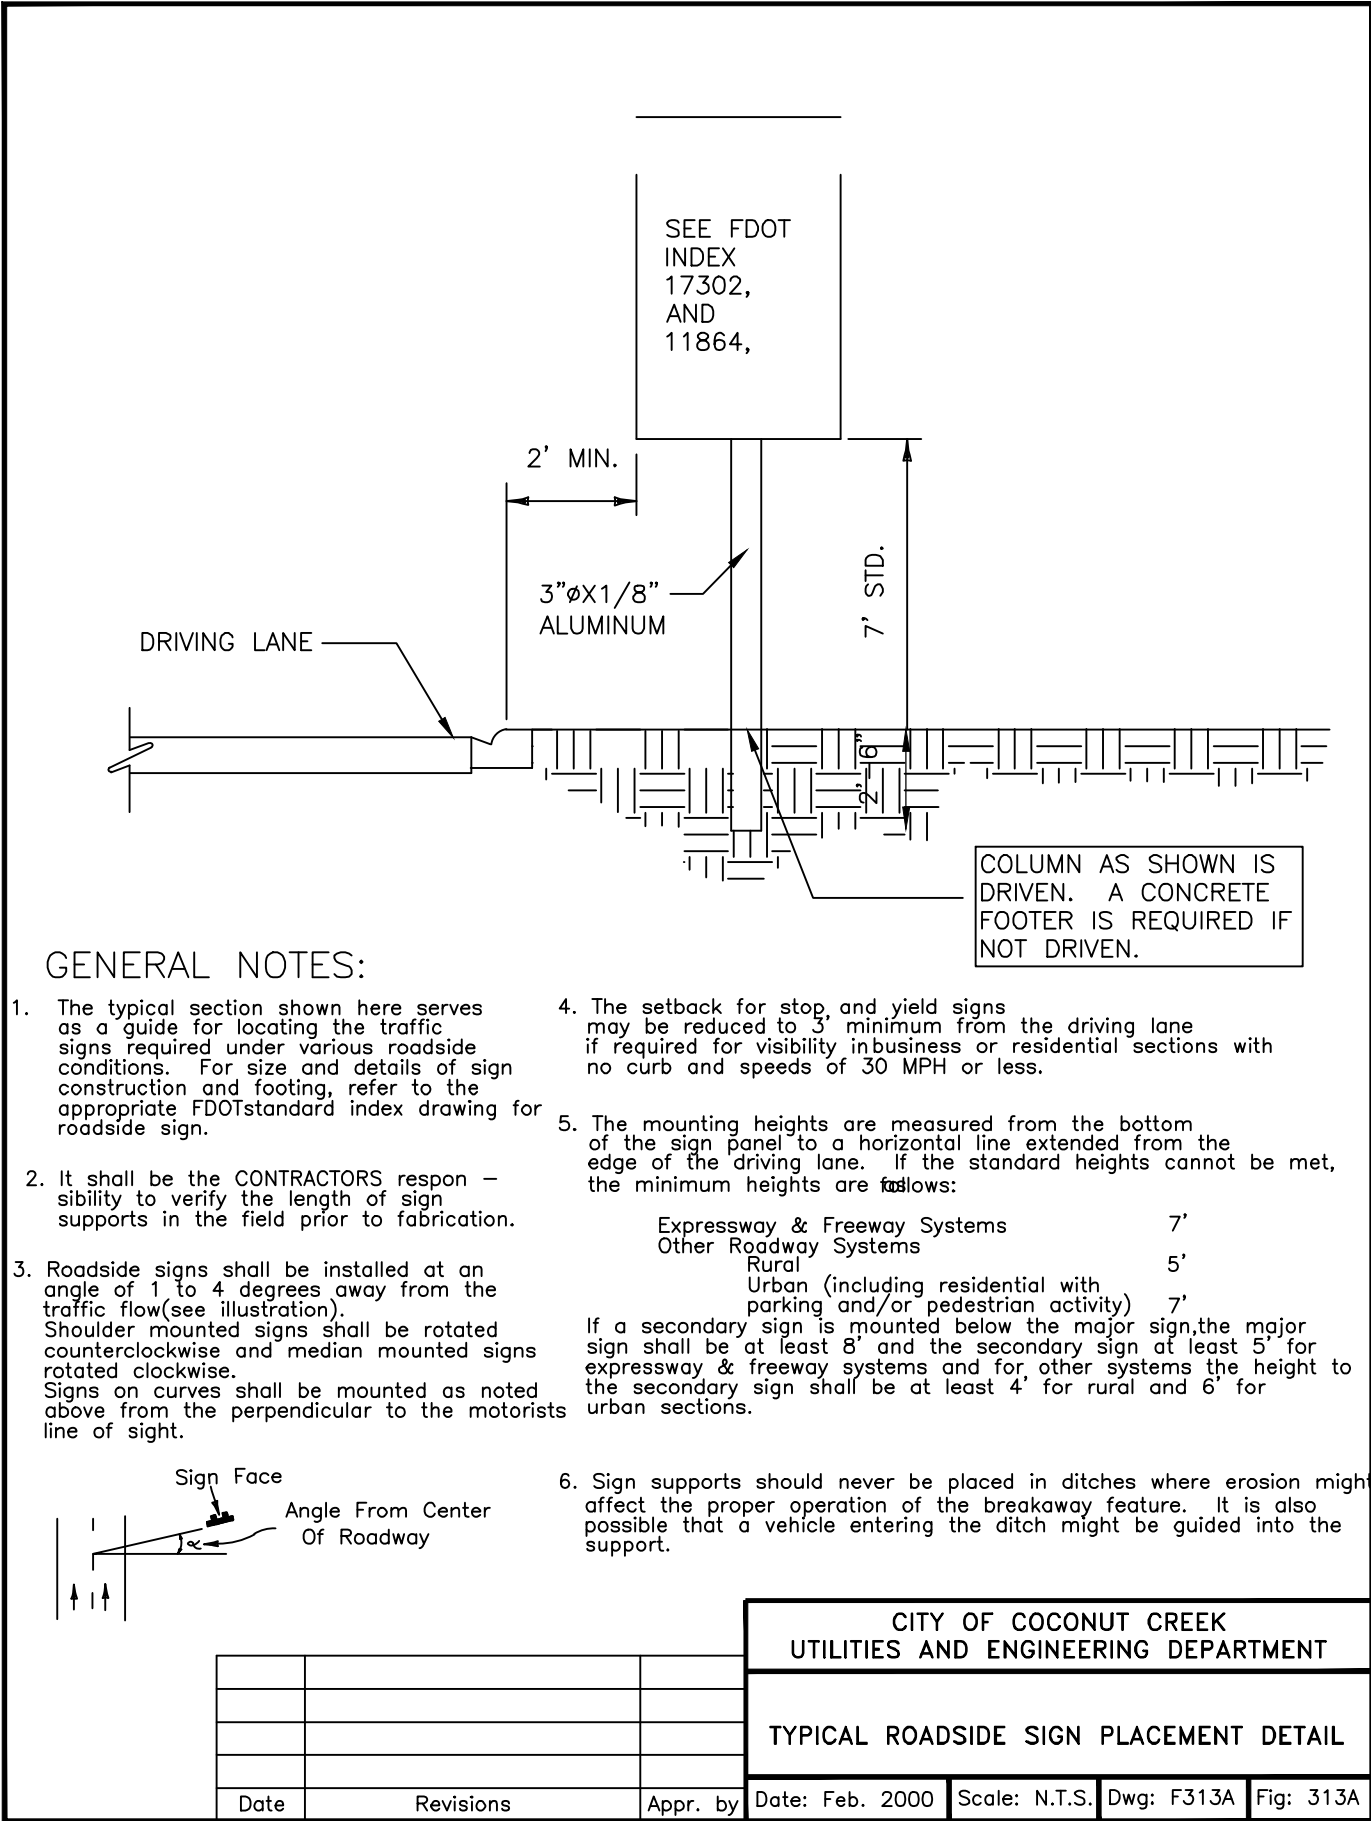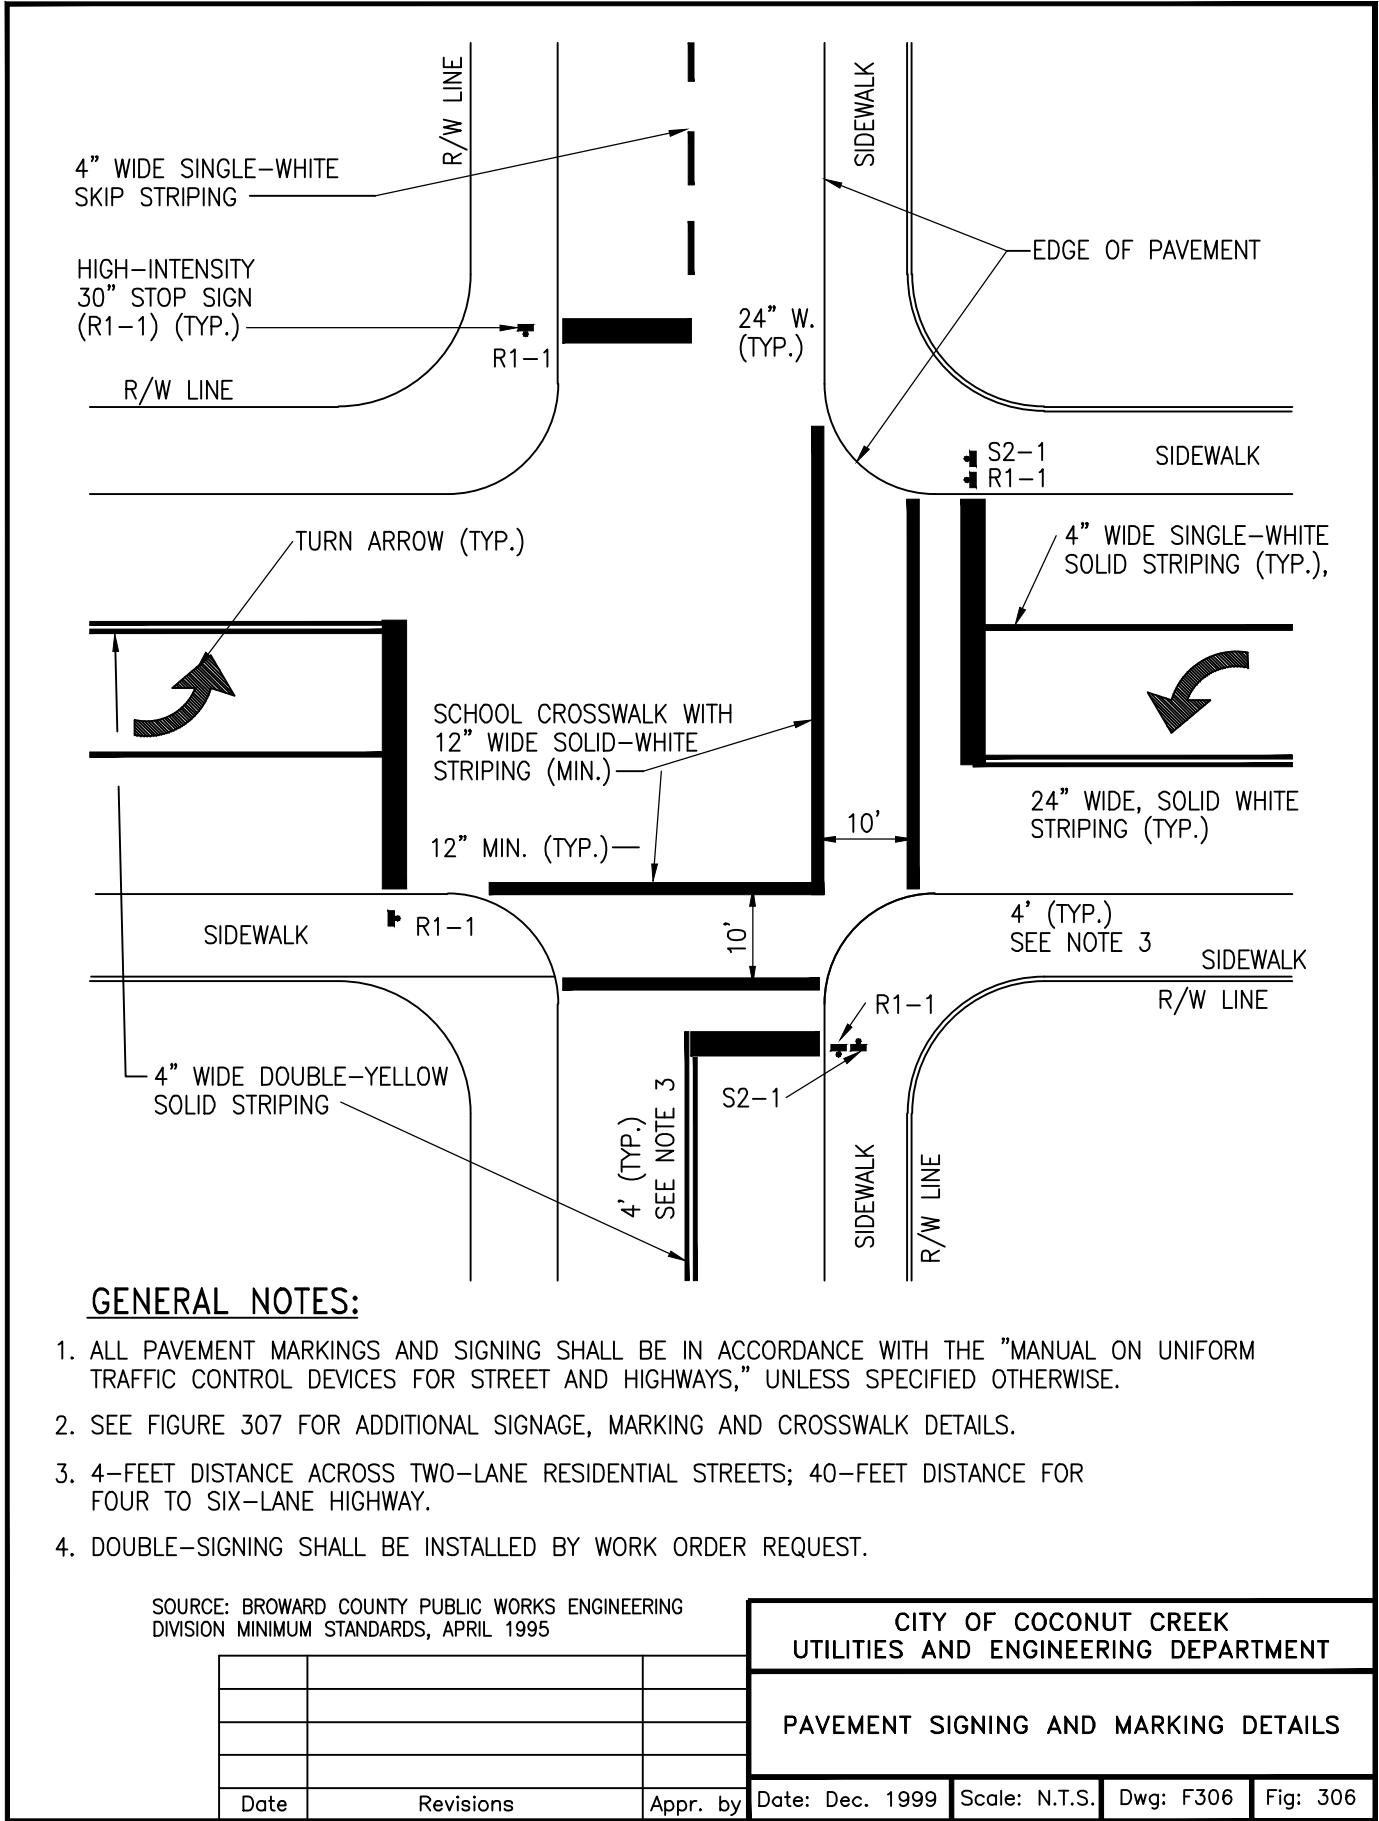

Broward County Traffic Engineering Division Communications Notes

To be placed within plan set

(Revised: 10/13/2015)

"Communications Notes"

The agency responsible for maintenance of the traffic signals and related equipment is Broward County Traffic Engineering Division (BCTED). All system communications equipment, cabling and related material shall comply with Broward County's latest edition of the minimum standards as expressed in the "Standards and Specifications - Communication Infrastructure" document. Please refer to (BCTED's) Communications Policies and Procedures for additional information. Broward County Traffic Engineering Division will not accept any projects that do not meet these standards and specifications. If fiber optic pull boxes already exist at an intersection, no additional fiber optic pull boxes will need to be installed. For a copy of these standards refer to the Broward County web site at www.BROWARD.ORG/TRAFFIC under publications.

If there are Copper Interconnect Cable/s within your project limits or within 1500 feet of your project limits, contact the Communications Manager at teccommunications@broward.org or 954-847-2745.

If there are Fiber Optic Cable/s within your project limits or within 1500 feet of your project limits contact the Communications Manager at teccommunications@broward.org or 954-847-2745.

If there are cellular communications within your project limits, contact the Communications Manager at teccommunications@broward.org or 954-847-2745

All BCTED communications cables/conduit shall be located a minimum of 48 hours in advance.

**Broward County Traffic Engineering Division
Procedure for Notification of Communication Disruption**

Copper Interconnect Cable Notification Contact Person

When communications to an intersection must be disrupted by a Contractor to perform work, the Contractor **shall** provide two day advance notice in writing to the Broward County Traffic Engineering Division. This notification **shall** be conveyed via electronic mail (**email**) to the Traffic Signal Technician III at teccommunications@broward.org. Notification **shall** include contact person, telephone number, purpose, location and duration. The disruption **shall** last for no more than 3 consecutive business days. Where possible, the disruption **shall** be during off peak hours beginning at 9:00am and ending at 3:00pm.

Fiber Optic Cable Notification Contact Person

When communications to an intersection must be disrupted by a Contractor to perform work, the Contractor **shall** provide two day advance notice in writing to the Broward County Traffic Engineering Division. This notification **shall** be conveyed via electronic mail (**email**) to the Communications Manager at teccommunications@broward.org. Notification **shall** include contact person, telephone number, purpose, location and duration. The disruption **shall** last for no more than 3 consecutive business days. Where possible, the disruption **shall** be during off peak hours beginning at 9:00am and ending at 3:00pm.

Include the following in any notice of utility ownership or within a "Utility Owners/Contact Person" table:

Interconnect Communications Cables - (Robert Blount) Broward County Traffic Engineering Division (BCTED) 954-847-2745



PUBLIC WORKS DEPARTMENT
TRAFFIC ENGINEERING DIVISION
2300 W. Commercial Boulevard • Fort Lauderdale, Florida 33309 • 954-847-2600 • FAX 954-847-2700

MAINTENANCE OF TRAFFIC - SCHOOL/PEDESTRIAN

The Maintenance of Traffic plan, provided by the Contractor, shall include provisions for pedestrian and/or school student traffic as well as vehicular traffic. The following are minimum requirements:

- The safe walk route for all school students within the vicinity of the construction zone shall be maintained during student arrival and dismissal times. If the current walking surface cannot be maintained, then a temporary walkable surface shall be created. The safe walk route shall be separated from the construction activity during the entire length of the project encompassing the entire walk route with proper pedestrian openings at designated crossings in compliance with FDOT Design Standards Index No. 600 as well as meeting all ADA requirements.
- All construction equipment activity around any designated crosswalk shall cease to operate during the student arrival and dismissal times. All construction equipment activity adjacent to a designated walk route shall cease operating unless satisfactorily barricaded from the walk route.
- In the case that a designated crossing or any portion of the designated walk route cannot be maintained, the Contractor shall notify the Special Projects Coordinator at Broward County Traffic Engineering Division, (954) 847-2600, a minimum of ten (10) working days prior to closing that route in order to establish an alternate crossing/route.
- It shall be the Contractor's responsibility to install any necessary pavement, road rock, pavement markings and signage and/or any pedestrian signalization and/or signal modification to accommodate an existing or alternate walk route throughout the entire length of the project.
- It shall be the Contractor's responsibility to provide State Certified School Crossing Guards or Off Duty Police Officers to cross students at all locations other than those previously designated. The Contractor may use Flagmen, but **ONLY** if they are State Certified as a School Crossing Guard.
- Thirty (30) days prior to the beginning of construction the Contractor shall notify the Special Projects Coordinator at Broward County Traffic Engineering Division, (954) 847-2600 or at trawards@traffic.org to discuss all necessary safety measures.
- It shall be the Contractor's responsibility to notify the following Broward County School Board Pupil Transportation Department personnel if construction will impact any bus routes:

• Ruth Masters Routing (754) 321-4400 Ext. # 2309 ruth.masters@browardschools.com
• Vincent Harrell Student Transportation & Fleet Service (754) 321-4472 vincent.harrell@browardschools.com
• Mary Tochtermann Student Transportation & Fleet Service (754) 321-4400 Ext. # 2006 mary.tochtermann@browardschools.com

Upon coordination with the aforementioned personnel, and if deemed necessary, a pre-construction meeting will be held to determine all bus routes and to make any necessary arrangements for rerouting. The Special Projects Coordinator from the Broward County Traffic Engineering Division, (954) 847-2600, will be notified and may attend the pre-construction meeting.

8. The Contractor shall be responsible for obtaining an approved Maintenance of Traffic Plan (MOT), specifying the above school/pedestrian conditions, through the Broward County Traffic Engineering Division or the Local Municipality, depending on the roadway jurisdiction. The conditions outlined in the MOT are fully effective as part of the proposed improvements. The Contractor shall be responsible for ensuring that all work associated with the project is in compliance with all the requirements of the approved MOT.

9. The Contractor shall ensure that there are **NO** speed limit signs installed within the designated reduced speed school zone at any time throughout the project.

Revised: 02/4/14



Maintenance of Traffic (MOT) Instructions/Requirements

An approved MOT Plan from the Broward County Traffic Engineering Division (BCTED) shall be required when work is being performed within Broward County Right of Way regardless of whether a permit is required. The approved MOT Plan shall be on site prior to and during the entire operation. Ensure the Certified Worksite Traffic Supervisor is present to direct the initial setup of the traffic control plan, is available on a 24-hour basis, participates in all changes to traffic control and reviews the project on a daily basis. An MOT plan shall conform to, unless otherwise noted in the Broward County Minimum Standards, the latest editions of the Florida Department of Transportation (FDOT) Design Standards 600 Series and the Manual on Uniform Traffic Control Devices (MUTCD). An approved MOT Plan and a copy of the permit, if issued, must be on site at all times. The MOT is valid for the duration of the permit or completion of the project, whichever comes first. Once the MOT is approved by the BCTED, the permittee shall be solely responsible for the installation and maintenance of the approved work zone traffic control devices throughout the length of the project.

Application Process for an MOT Plan:

- Include an MOT Application Form.
- Include a location map for the project.
- Submit an applicable FDOT Design Standard Index from the 600 Series and/or a Typical Application figure from the MUTCD which represents the roadway characteristics and project conditions.
 - For example:
 - If the project involves the closure of a sidewalk, include a sidewalk closure index.
 - If the project does not impede a lane but is within the right of way, include the appropriate index for work off the road.
 - If the project requires a lane shift, include a lane shift index.
- A sketch should accompany the submittals for a condition that is non-typical. Include taper lengths, shift lengths, shift widths, sign spacing, barricade or cone spacing, pavement markings, removal of pavement markings, nearby signal locations, etc..
- Indexes, Typical Applications or sketches shall have the roadways identified by name and show a north arrow.
- Applications shall include a current FDOT-approved certification for Worksite Traffic Supervisor. If you are submitting an MOT Plan with an FDOT Design Standards 600 Series Index or a Typical Application figure from the MUTCD, an Intermediate Level Certification Card will be required; if a sketch is submitted with the standard index, an Advanced Level Certification Card will be required. The certification card is required to contain the student's name, instructor's name, course provider, course category (Advance: BT-05-0079 or Intermediate: BT-05-0078), date course was successfully completed and date when training or refresher course is required.
- The FDOT Standard Index has notes in small print included on them. When sending these indexes, ensure the notes are legible.
- The MOT Plan must cover all phases of construction.
- If the project includes a sign-off sheet, it must be labeled with the project's name and/or location of the project.

The following document will be required prior to the approval of the MOT plan when signal equipment is impacted: A filled out and signed form of ACCEPTANCE OF TRAFFIC SIGNAL MAINTENANCE AND TIMING BY CONTRACTOR DURING CONSTRUCTION AND BURN-IN PERIOD. The form can be downloaded under the category of Maintenance of Traffic in the webpage of <http://www.broward.org/Traffic/About/Pages/Publications.aspx>.

The approval of an MOT application may require up to (2) weeks from the time that all required documents as stated above are received at the Traffic Engineering Division. Any rejected MOT submittal that is corrected and sent back to BCTED will be considered a new submittal, which may require up to two (2) additional weeks to approve. Additional time may be needed for more complex plans or plans requiring additional coordination/information.

G:\STUDIES\MOT\MOT Application Form\MOT Application Form 09-30-16.doc
Page 1

Revised 09/16



Maintenance of Traffic Application Form

Date _____ Broward County Permit Number (if required) _____

Contractor _____ Address _____

City _____ State _____ Zip _____ Office # _____

Mobile # _____ Fax # _____

Full name and Mobile # of 24 hr Contact Person _____

Name of Contractors working under this approval: _____

Location of Project: _____ City: _____

Project Boundaries, From _____ To _____

Description of Work: _____

Proposed Start Date: _____ Proposed Completion Date: _____

Authorized Contractor's Representative _____

(Print Name) (Signature) (Date)

A copy of the certification card(s) shall be included with every MOT Plan

(Print Name of Certified Person Submitting MOT) (Level) (Signature) (Date)

(Print Name of Certified Person Setting Up MOT) (Level) (Signature) (Date)

(Print Name of Certified Person Maintaining MOT) (Level) (Signature) (Date)

(Print Name of Certified Person in Charge of Flagging Operation MOT) (Level) (Signature) (Date)

The following document will be required prior to the approval of the MOT plan when signal equipment is impacted:

A filled out and signed form of ACCEPTANCE OF TRAFFIC SIGNAL MAINTENANCE AND TIMING BY CONTRACTOR DURING CONSTRUCTION AND BURN-IN PERIOD. The form can be downloaded under the category of Maintenance of Traffic in the webpage of <http://www.broward.org/Traffic/About/Pages/Publications.aspx>

G:\STUDIES\MOT\MOT Application Form\MOT Application Form 09-30-16.doc
Page 2

Revised 09/16

**LEDER
HILLSBORO
STORAGE**

SCALE: AS NOTED

DATE ISSUED: JANUARY 31, 2018

DRAWN BY: MG

DESIGNED BY: MG

CHECKED BY: SW

STEPHEN D. WILLIAMS, P.E.
FLORIDA REG. NO. 32090
(FOR THE FIRM)

SHEET TITLE

**PAVEMENT
MARKING AND
SIGNAGE DETAILS**


SHEET NUMBER

CM-502

SHEET 25 of 27


PROJECT NO. 09675.00

- GUIDE TO USE THIS STANDARD:**
- Calculate the Total Panel Area and the centroid 'C' for an individual sign or a sign cluster.
 - Determine the height 'H' from the groundline for the individual sign or the cluster.
 - Consult the Post Size Table and find the intersection point.
 - Design the post and the foundation according to the required Post Size and Assembly Details.

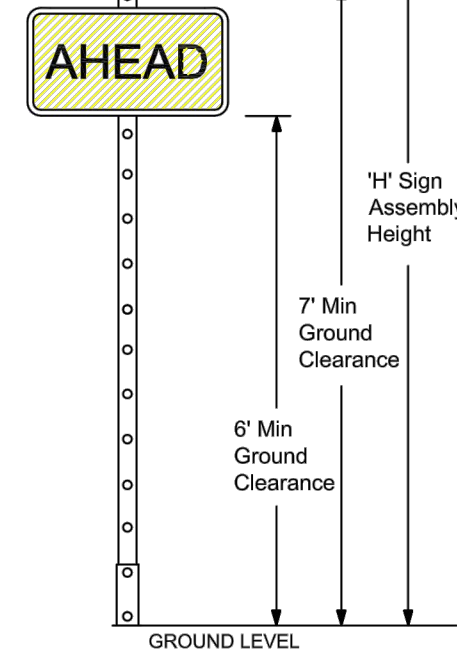


Post Size Table						
		'H' Sign Assembly Height (ft) (measure from ground)				
		8	8.5	9	9.5	10
Total Panel Area (sf)	3					
	4					
	5					
	6					
	7					
	8					
	9					
	10					
	11					
	12					
	13					
Total Panel Area (sf)	14					
	15					
	16					
	17					
	18					
	19					
	20+					

Sign Post with 3" x 7 ga. Square Anchor

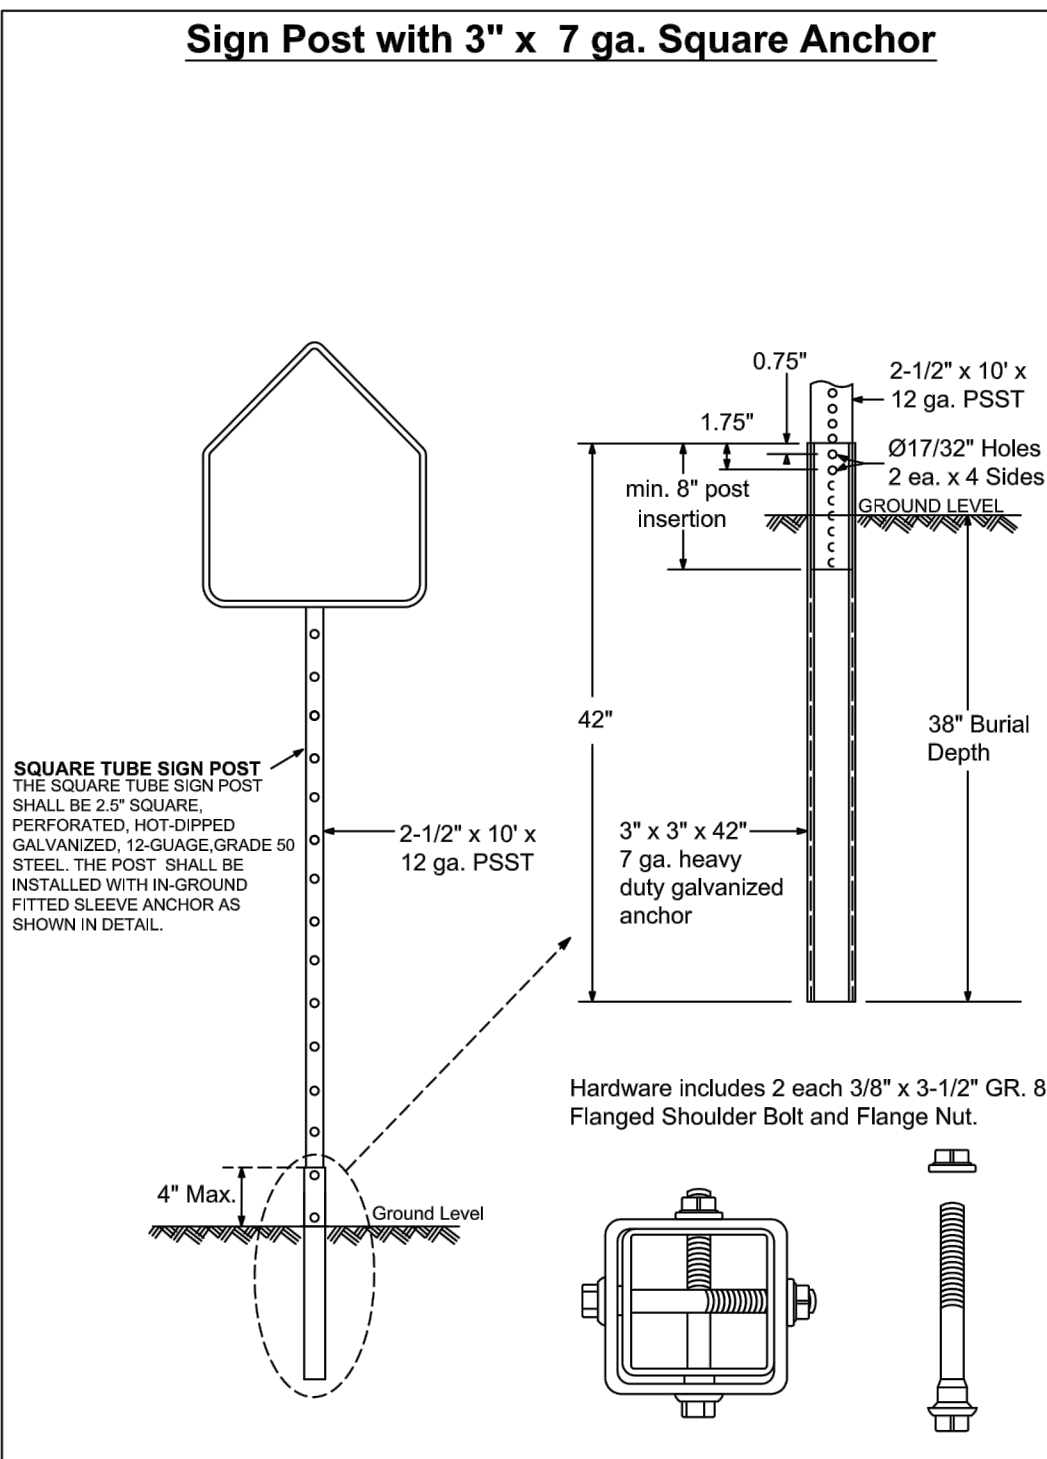

Sign Post with Triangular Slip Base

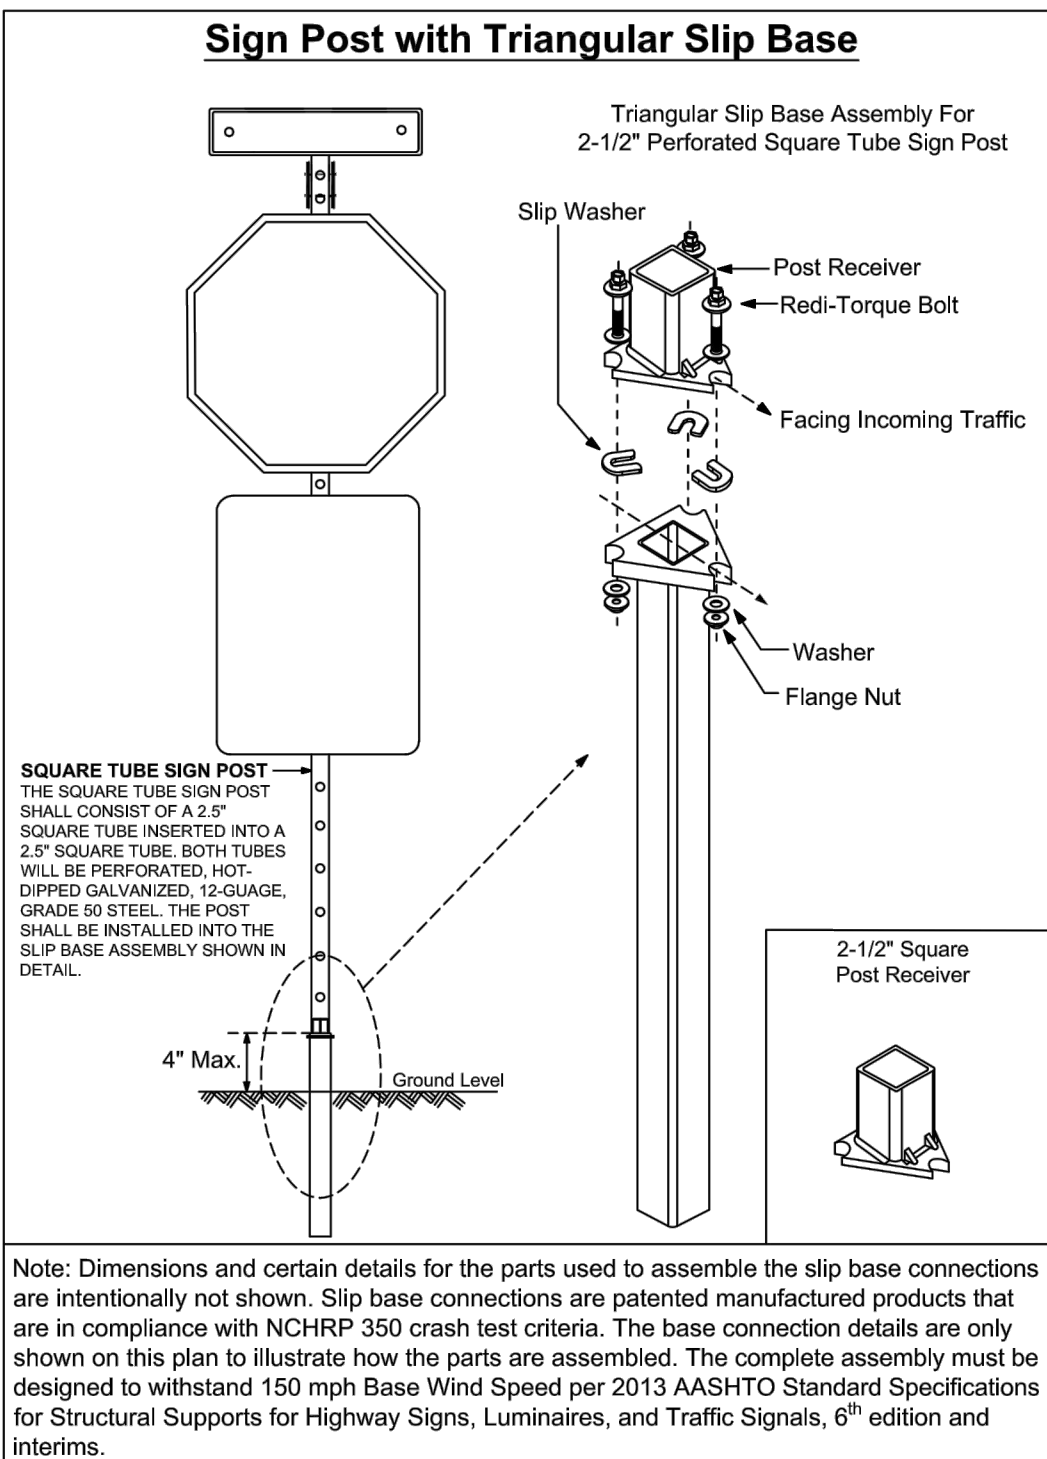

Note: Dimensions and certain details for the parts used to assemble the slip base connections are intentionally not shown. Slip base connections are patented manufactured products that are in compliance with NCHRP 350 crash test criteria. The base connection details are only shown on this plan to illustrate how the parts are assembled. The complete assembly must be designed to withstand 150 mph Base Wind Speed per 2013 AASHTO Standard Specifications for Structural Supports for Highway Signs, Luminaires, and Traffic Signals, 6th edition and interims.

**GROUND SIGN ASSEMBLY
DETAILS**

SHEET
NO.

1 OF 1

ALL ON-SITE SIGNS SHALL BE IN
ACCORDANCE WITH BROWARD COUNTY
"STOP SIGN AND STREET IDENTIFICATION
ASSEMBLY TYPICAL DETAILS".

ALL SIGNS WITHIN FDOT
RIGHT-OF-WAY SHALL BE IN
ACCORDANCE WITH FDOT INDEX 11860

